

INDEX OF PLANS

SHEET No.	DESCRIPTION
1	TITLE AND LOCATION MAP
2	TYPICAL CROSS SECTIONS
3	CONSTRUCTION DETAILS
4	CONSTRUCTION AREA SIGNS
5	SUMMARY OF QUANTITIES
6	MODIFY VEHICLE CLASSIFICATION STATION
7	ELECTRICAL DETAILS
8-20	REVISED STANDARD PLANS


THE STANDARD PLANS LIST APPLICABLE TO THIS CONTRACT IS INCLUDED IN THE NOTICE TO BIDDERS AND SPECIAL PROVISIONS BOOK.

STATE OF CALIFORNIA
DEPARTMENT OF TRANSPORTATION

ACSTP-P033(082)E

PROJECT PLANS FOR CONSTRUCTION ON
STATE HIGHWAY
IN FRESNO COUNTY IN AND NEAR COALINGA
FROM 0.1 MILE WEST OF JACALITOS CREEK BRIDGE
TO 0.1 MILE WEST OF MERCED AVENUE AND
FROM 0.1 MILE NORTH OF PHELPS AVENUE TO
0.8 MILE NORTH OF PALMER AVENUE

TO BE SUPPLEMENTED BY STANDARD PLANS DATED 2010

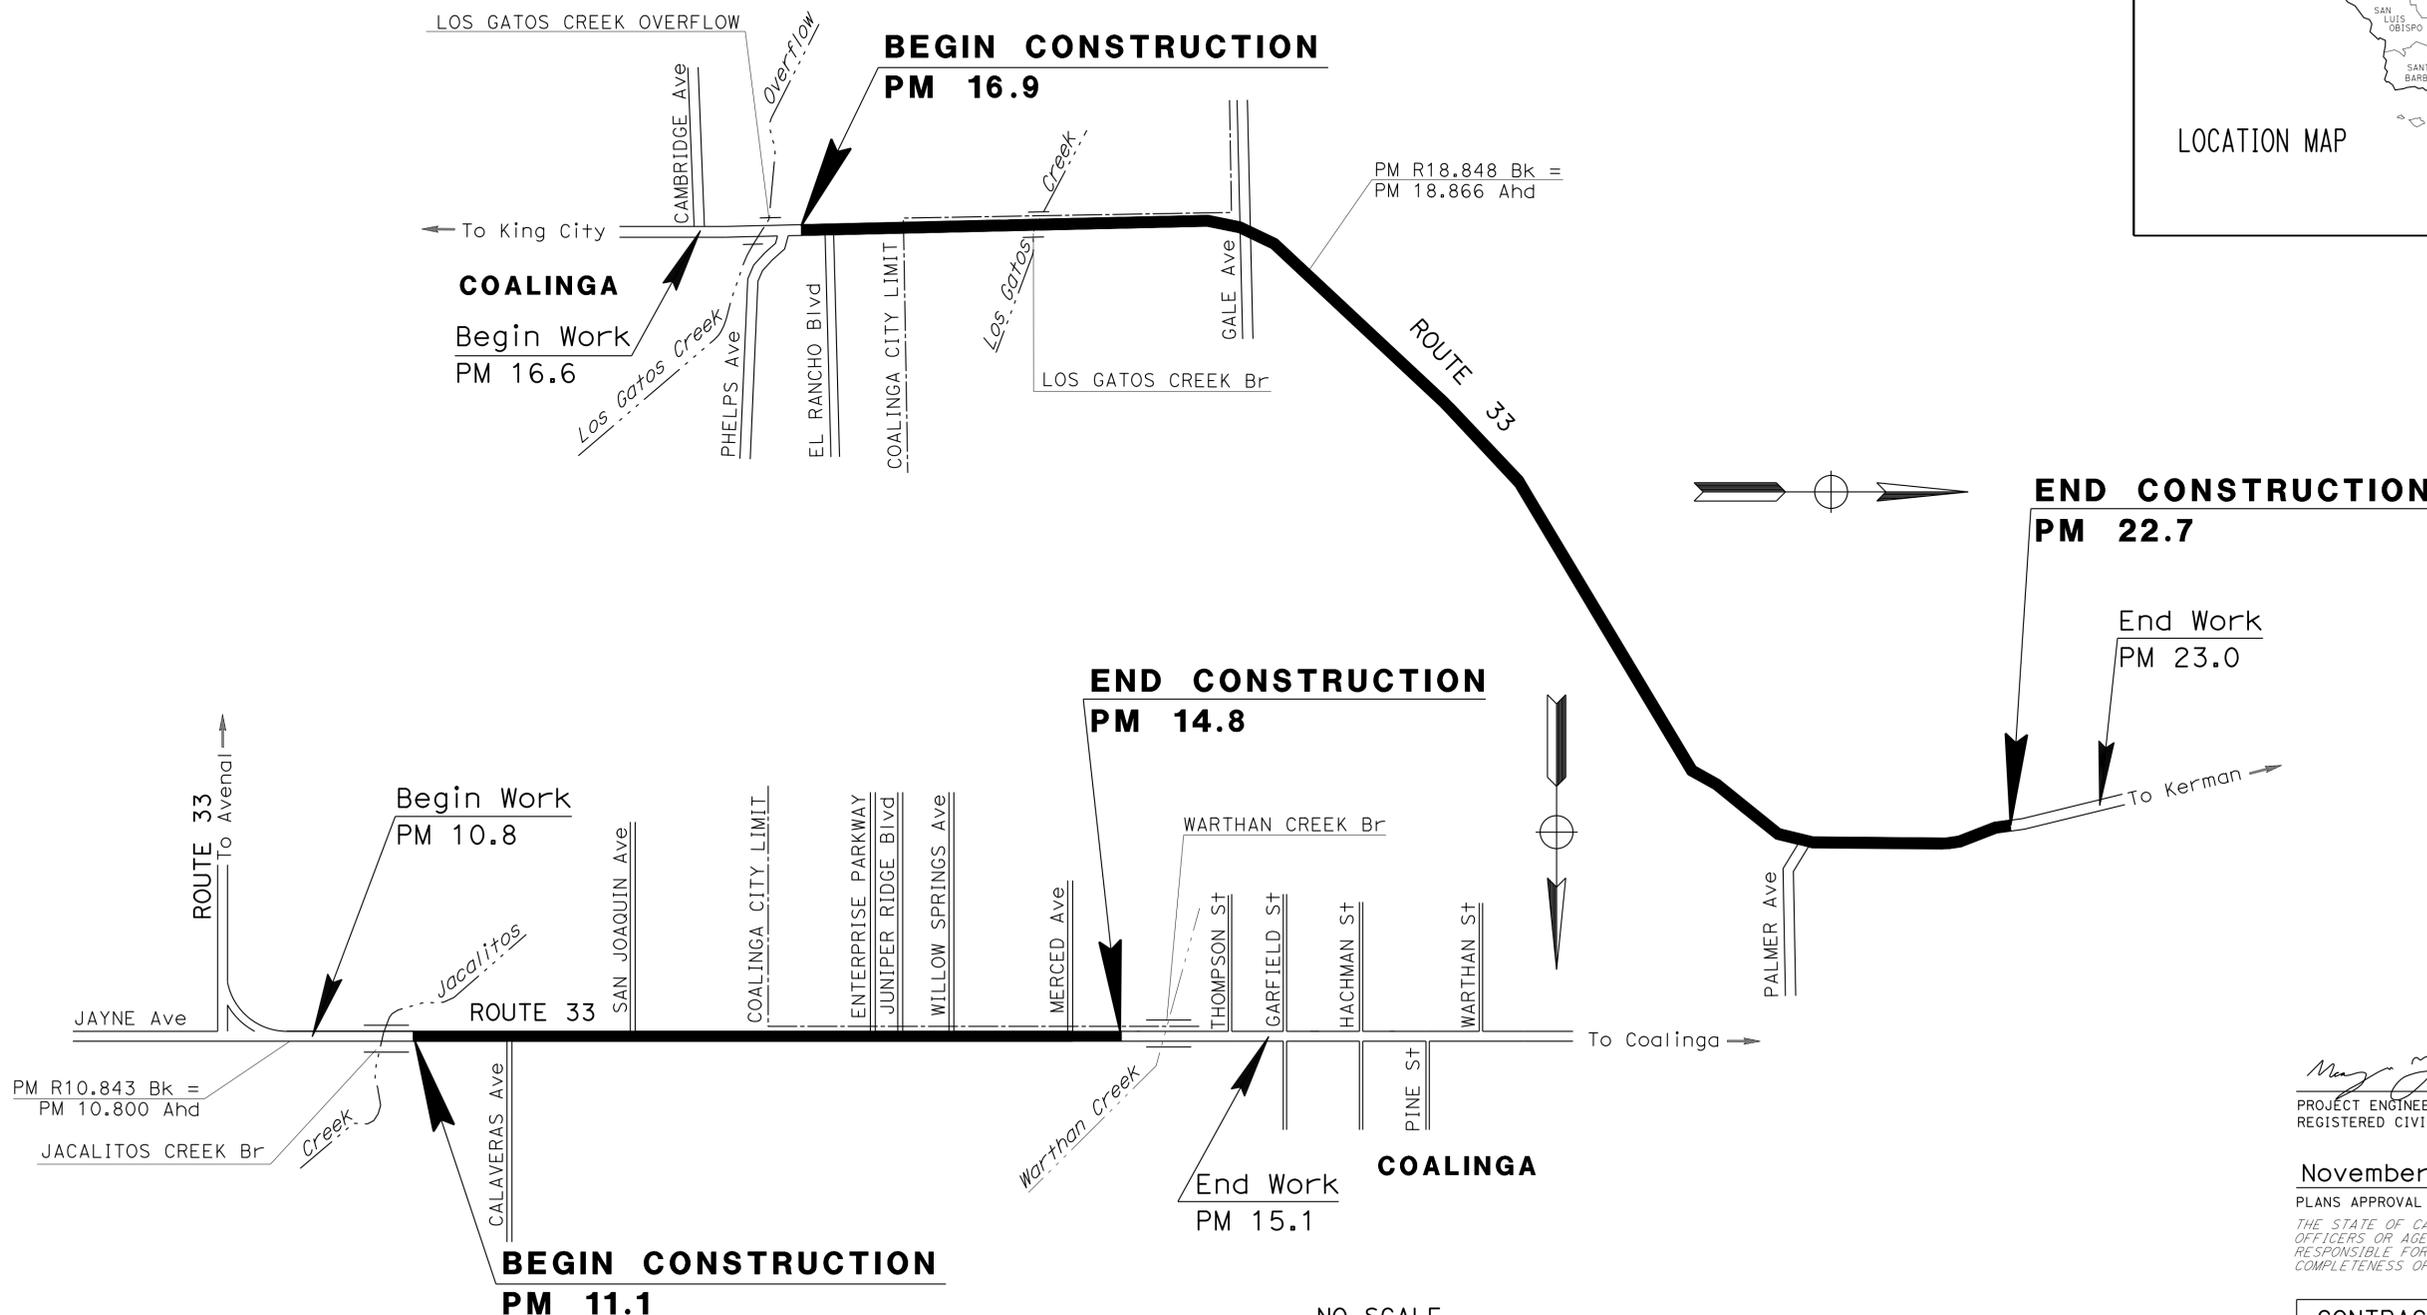

PROJECT MANAGER
VICTOR SHAW
DESIGN ENGINEER
RENE SANCHEZ

PROJECT ENGINEER
REGISTERED CIVIL ENGINEER
MAYYAM RASTEGAR
No. 65550
Exp. 9-30-17
CIVIL
STATE OF CALIFORNIA
DATE: 10-28-15
PLANS APPROVAL DATE: November 2, 2015
THE STATE OF CALIFORNIA OR ITS OFFICERS OR AGENTS SHALL NOT BE RESPONSIBLE FOR THE ACCURACY OR COMPLETENESS OF SCANNED COPIES OF THIS PLAN SHEET.

CONTRACT No. 06-OT6204
PROJECT ID 0615000218

THE CONTRACTOR SHALL POSSESS THE CLASS (OR CLASSES) OF LICENSE AS SPECIFIED IN THE "NOTICE TO BIDDERS."

NO SCALE

STATE OF CALIFORNIA - DEPARTMENT OF TRANSPORTATION
Caltrans
 PAVEMENT PRESERVATION
 FUNCTIONAL SUPERVISOR: RENE SANCHEZ
 MARYAM RASTEGAR
 RENE SANCHEZ
 REVISOR: MARYAM RASTEGAR
 DATE: 11-02-15
 DESIGNED BY: MARYAM RASTEGAR
 CHECKED BY: RENE SANCHEZ


NOTES:

1. DIMENSIONS OF THE PAVEMENT STRUCTURES (STRUCTURAL SECTIONS) ARE SUBJECT TO TOLERANCES SPECIFIED IN THE STANDARD SPECIFICATIONS.
2. FOR ACCURATE RIGHT OF WAY DATA, CONTACT RIGHT OF WAY ENGINEERING AT THE DISTRICT OFFICE.
3. EXISTING UTILITY FACILITIES HAVE NOT BEEN PLOTTED ON THESE PLANS.
4. USE DETAIL A AT EXISTING DIKE LOCATIONS.


**PAVEMENT CLIMATE REGION
 INLAND VALLEY**

DIST	COUNTY	ROUTE	POST MILES TOTAL PROJECT	SHEET No.	TOTAL SHEETS
06	Fre	33	11.1/14.8, 16.9/22.7	2	20

REGISTERED CIVIL ENGINEER DATE: 10-28-15
 MARYAM RASTEGAR
 No. 65550
 Exp. 9-30-17
 CIVIL
 THE STATE OF CALIFORNIA OR ITS OFFICERS OR AGENTS SHALL NOT BE RESPONSIBLE FOR THE ACCURACY OR COMPLETENESS OF SCANNED COPIES OF THIS PLAN SHEET.

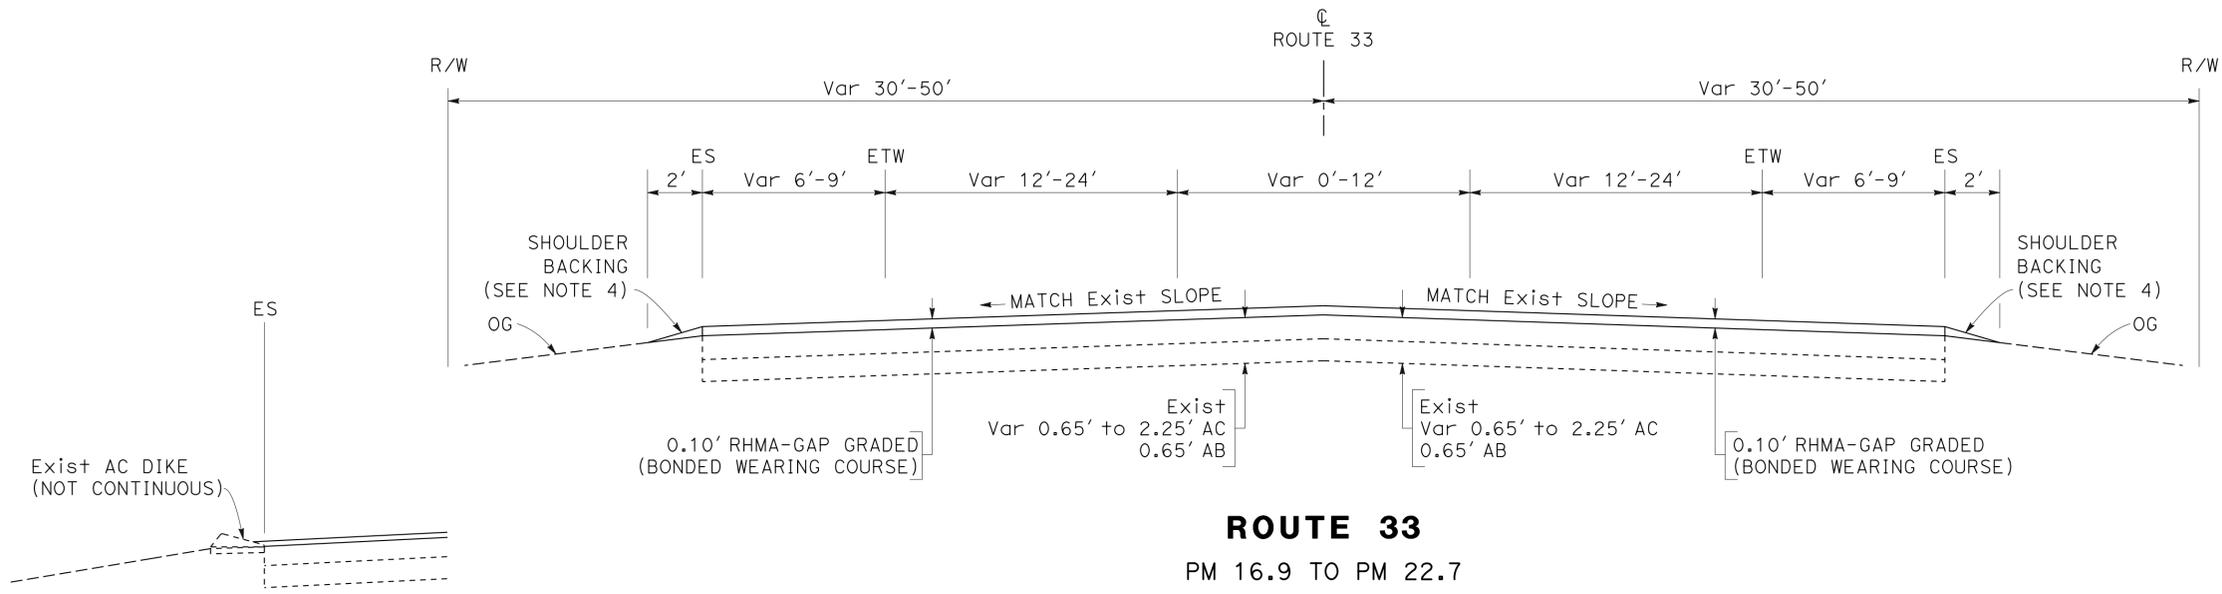


DETAIL A
 TYPICAL EDGE OF PAVEMENT
 AT EXISTING DIKE DETAIL

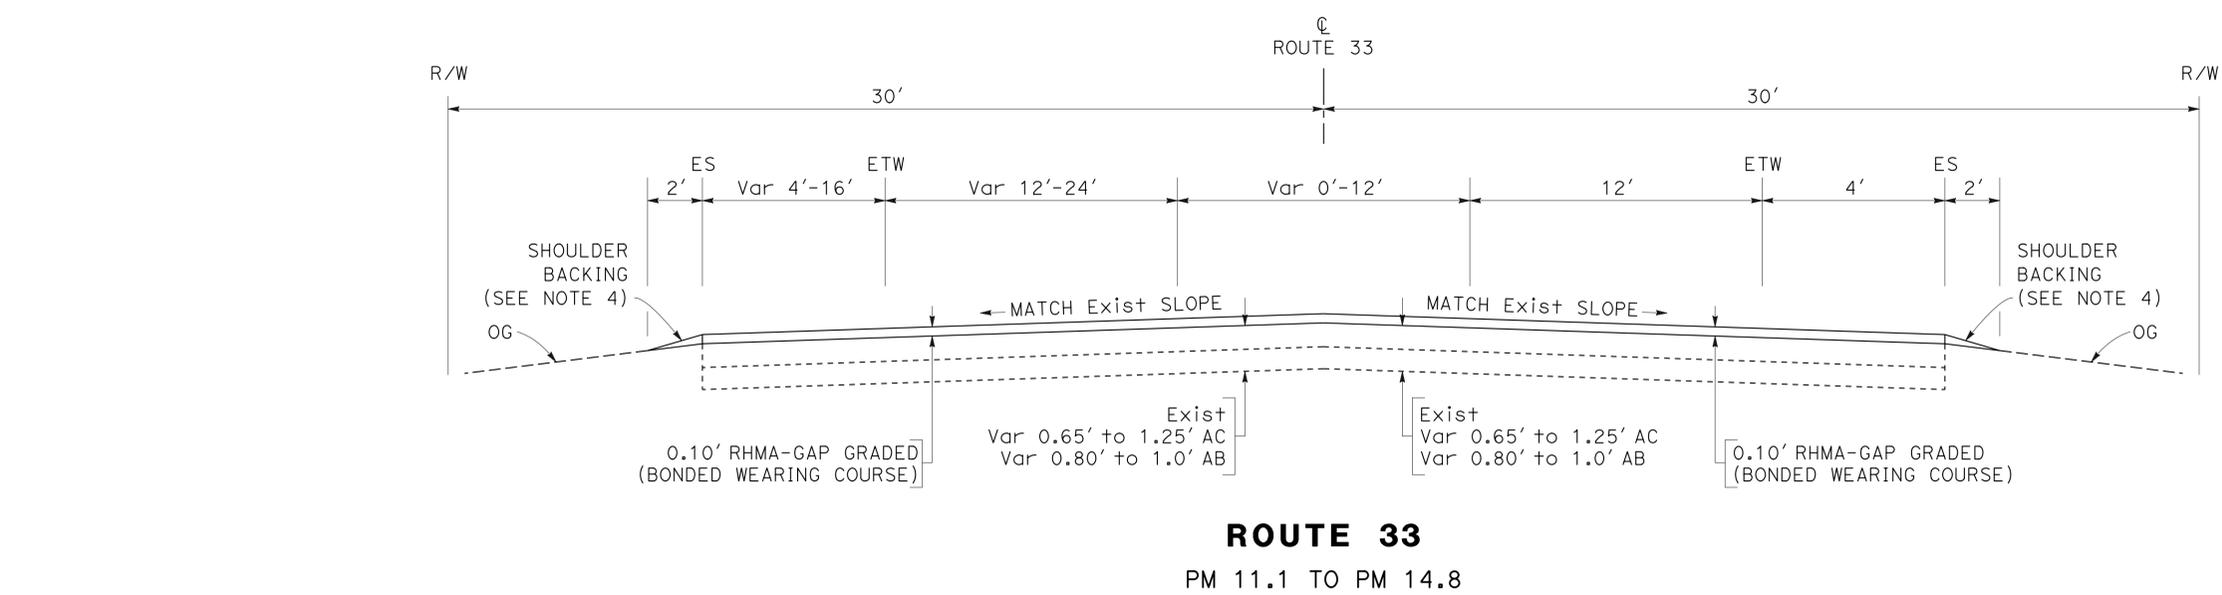

TYPICAL CROSS SECTIONS



NO SCALE

 X-1




LEGEND:

- RUBBERIZED HMA-GAP GRADED (BONDED WEARING COURSE)
- COLD PLANE AC PAVEMENT
- DIRECTION OF TRAFFIC

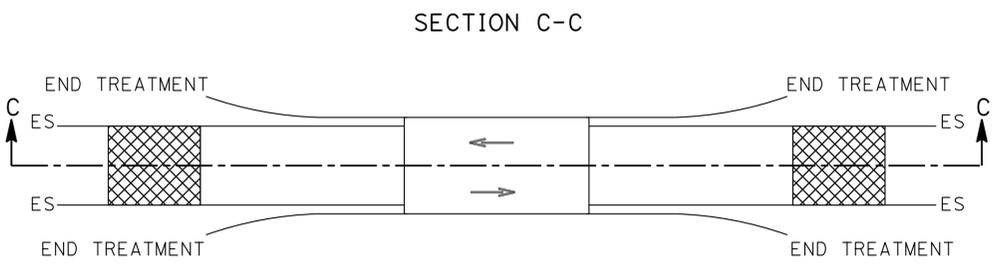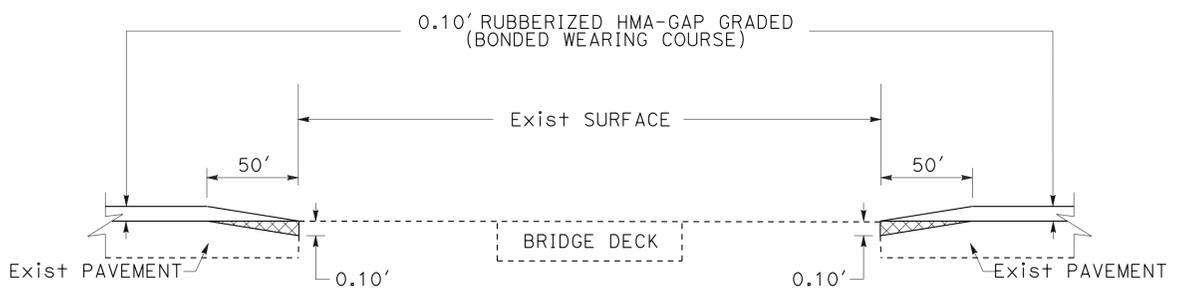

CONFORM TAPER AT LOS GATOS CREEK BRIDGE
PM 17.8


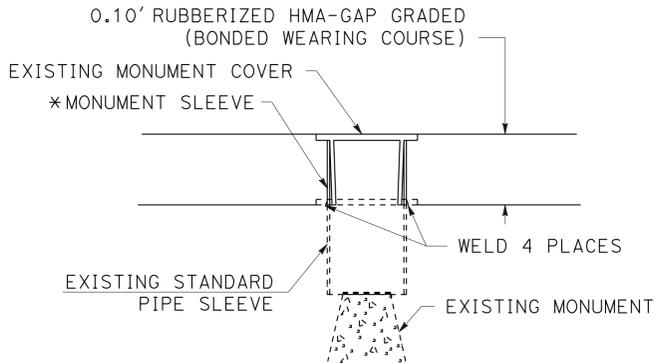


ADJUST MONUMENT COVER
* HEIGHT OF MONUMENT SLEEVE TO BE DETERMINED AFTER PLACING RUBBERIZED HMA-GAP GRADED (BONDED WEARING COURSE)



SURVEY MONUMENT LOCATIONS

POST MILE	PROTECT IN PLACE (N)	ADJUST MONUMENT COVER	DESCRIPTION
11.4	1		1.5" IRON PIPE
11.8	1		1.5" IRON PIPE
12.4	1		1.5" IRON PIPE
12.8	1		1.5" IRON PIPE
13.4	1		1.5" IRON PIPE
13.8	1		BRASS CAP
14.3	1		1.5" IRON PIPE
14.4		1	BRASS CAP
14.8	1		BRASS CAP
22.3		1	BRASS CAP
22.4		1	BRASS CAP
22.5		1	BRASS CAP
22.6		1	BRASS CAP
22.6		1	BRASS CAP
22.7		1	BRASS CAP

(N) NOT A SEPARATE PAY ITEM, FOR INFORMATION ONLY.

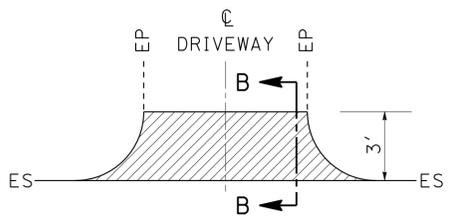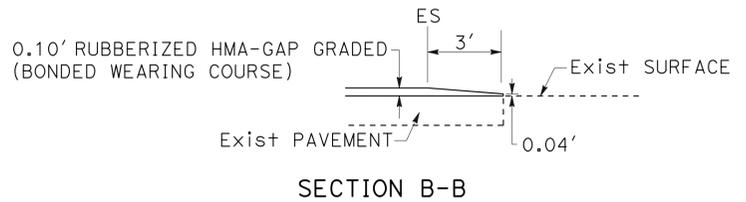


TYPICAL CONFORM TAPER AT DRIVEWAY
 PM 13.4 PM 21.1 PM 22.5
 PM 17.6 PM 21.7
 PM R19.6 PM 22.4

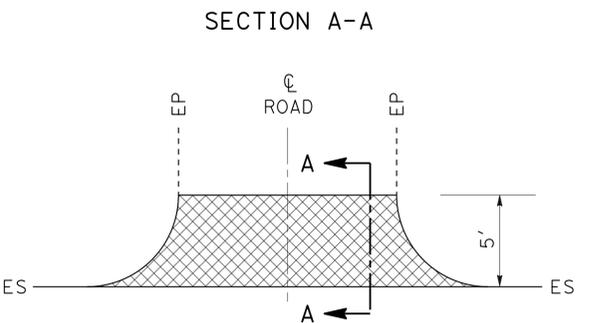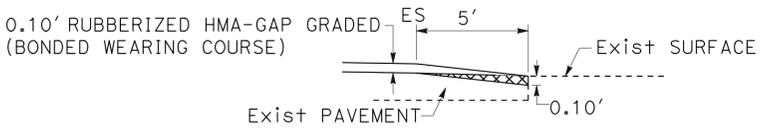


TYPICAL CONFORM TAPER AT LOCAL ROAD
 PM 11.3 PM 14.0 PM 17.0
 PM 12.7 PM 14.2 PM R18.6
 PM 13.9 PM 14.7 PM 21.8


CONSTRUCTION DETAILS
NO SCALE **C-1**

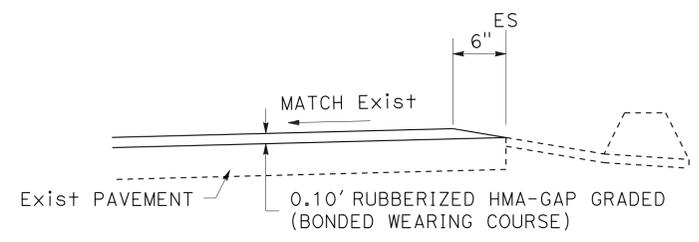

TYPICAL CONFORM TAPER AT SUPER DITCH

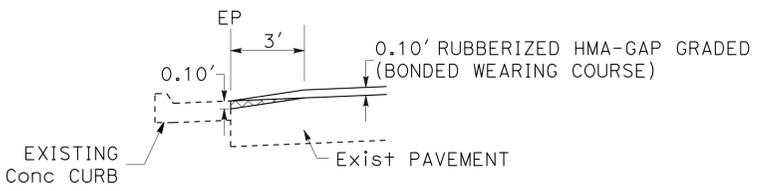

TYPICAL CONFORM TAPER AT CONCRETE CURB
PM 14.2

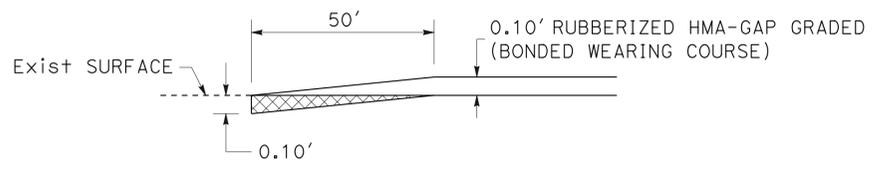

TYPICAL CONFORM TAPER AT Beg/END OVERLAY
 PM 11.1
 PM 14.8
 PM 16.9
 PM 22.7

STATE OF CALIFORNIA - DEPARTMENT OF TRANSPORTATION
PAVEMENT PRESERVATION
 MARYAM RASTEGAR
 RENE SANCHEZ
 RENE SANCHEZ
 RENE SANCHEZ

Dist	COUNTY	ROUTE	POST MILES TOTAL PROJECT	SHEET No.	TOTAL SHEETS
	Fre	33	11.1/14.8, 16.9/22.7	5	20

10-28-15
 REGISTERED CIVIL ENGINEER DATE
 11-02-15
 PLANS APPROVAL DATE

THE STATE OF CALIFORNIA OR ITS OFFICERS
 OR AGENTS SHALL NOT BE RESPONSIBLE FOR
 THE ACCURACY OR COMPLETENESS OF SCANNED
 COPIES OF THIS PLAN SHEET.

ROADWAY QUANTITIES

LOCATIONS	RHMA-GAP GRADED (BONDED WEARING COURSE)	ASPHALTIC EMULSION MEMBRANE (BONDED WEARING COURSE)	COLD PLANE ASPHALT CONCRETE PAVEMENT	SHOULDER BACKING	ADJUST MONUMENT COVER
	TON	TON	SQYD	TON	EA
PM 11.1 TO PM 14.8	5,061	72		312	1
PM 16.9 TO PM 22.7	9,982	141		413	6
CONFORM TAPER	60	2	2186		
TOTAL	15,103	215	2186	725	7

PAVEMENT DELINEATION QUANTITIES

LOCATIONS	DETAIL No.	PAVEMENT MARKER (RETROREFLECTIVE)			THERMOPLASTIC TRAFFIC STRIPE					THERMOPLASTIC PAVEMENT MARKING		REMOVE THERMOPLASTIC PAVEMENT MARKING	REMOVE THERMOPLASTIC TRAFFIC STRIPE	REMOVE PAVEMENT MARKER (N)
		TYPE D TWO-WAY YELLOW	TYPE G ONE-WAY CLEAR	TYPE H ONE-WAY YELLOW	4" (BROKEN 12-3)	4" (BROKEN 36-12)	4" WHITE	4" YELLOW	8" WHITE	DESCRIPTION	SQFT	SQFT	LF	EA
		EA	EA	EA	LF	LF	LF	LF	LF					
PM 11.1 TO PM 14.8	6	253		71		12,118				LIMIT LINE	207	207		253
	19	38				1,686		1,686		2-TYPE III (R) ARROW	84	84		109
	22	204						4,810		8-TYPE III (L) ARROW	336	336		204
	27B							38,202		7-STOP	154	154		
	27C				870									
	29	256							12,104					256
	38		65						1532				3064	65
PM 16.9 TO PM 22.7	6	267				12,771				LIMIT LINE	210	210		267
	19	108		211		5,045		5,045		15-TYPE III (L) ARROW	630	630		319
	22	580						13,844		6-TYPE III (R) ARROW	252	252		580
	27B							60,429		1-TYPE V ARROW	33	33		
	27C				819					1-SIGNAL	32	32		
	29	454						21,680		1-AHEAD	31	31		454
	38		118						2804	5-STOP	110	110	5608	118
SUB TOTAL		2160	183	282	1689	31,620	98,631	59,169	4336		2079	2079	8672	
TOTAL			2625		1689	31,620	157,800		4336		2079	2079	8672	

(N) NOT A SEPARATE PAY ITEM, FOR INFORMATION ONLY.

SUMMARY OF QUANTITIES

Q-1

STATE OF CALIFORNIA - DEPARTMENT OF TRANSPORTATION
Caltrans
 PAVEMENT PRESERVATION
 FUNCTIONAL SUPERVISOR
 RENE SANCHEZ
 CALCULATED-DESIGNED BY
 CHECKED BY
 MARYAM RASTEGAR
 RENE SANCHEZ
 REVISED BY
 DATE REVISED

Dist	COUNTY	ROUTE	POST MILES TOTAL PROJECT	SHEET No.	TOTAL SHEETS
06	Fre	33	11.1/14.8 16.9/22.7	6	20

David C. Arias 09-02-15
 REGISTERED ELECTRICAL ENGINEER DATE
 11-02-15
 PLANS APPROVAL DATE

THE STATE OF CALIFORNIA OR ITS OFFICERS
 OR AGENTS SHALL NOT BE RESPONSIBLE FOR
 THE ACCURACY OR COMPLETENESS OF SCANNED
 COPIES OF THIS PLAN SHEET.

LEGEND: (FOR THIS SHEET ONLY)


 
- 1 AB Exist DETECTOR LOOPS.
- 2 SEE DETAILS A AND B ON SHEET E-2 FOR DETECTOR LOOP AND PIEZO AXLE SENSOR IDENTIFICATION AND INSTALLATION.

NOTE:

1. FOR ACCURATE RIGHT OF WAY DATA, CONTACT RIGHT OF WAY ENGINEERING AT THE DISTRICT OFFICE.

ABBREVIATION:

STC SCREENED TRANSMISSION CABLE.

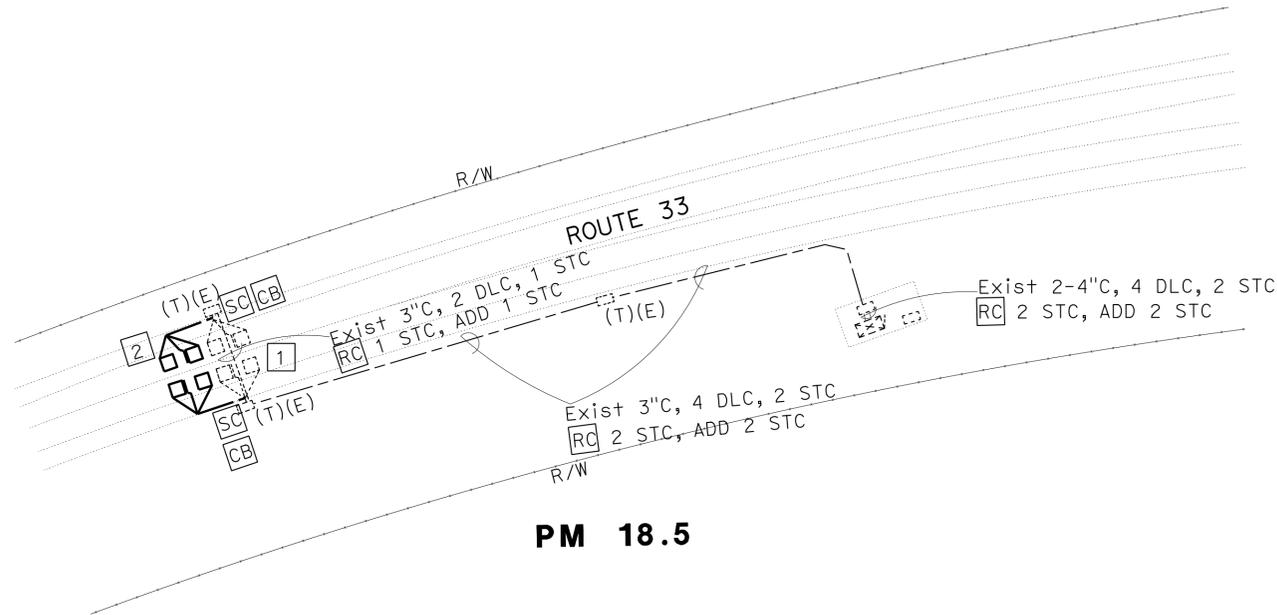

MODIFY VEHICLE CLASSIFICATION STATION QUANTITIES

SHEET No.	TYPE A DETECTOR LOOP	PIEZO AXLE SENSOR WITH STC
	EA	
E-1	4	2

THE QUANTITIES SHOWN ON THIS TABLE ARE NOT SEPARATE PAY ITEMS, FOR INFORMATION ONLY. FOR COMPLETE ELECTRICAL WORK, SEE ELECTRICAL PLAN SHEETS.



MODIFY VEHICLE CLASSIFICATION STATION E-1

APPROVED FOR ELECTRICAL WORK ONLY

SCALE: 1" = 50'

STATE OF CALIFORNIA - DEPARTMENT OF TRANSPORTATION
Caltrans MAINTENANCE DESIGN
 ARTURO ARIAS
 DAVID C. ARIAS
 FRANK GONZALEZ


STATE OF CALIFORNIA - DEPARTMENT OF TRANSPORTATION
Caltrans MAINTENANCE DESIGN
 FUNCTIONAL SUPERVISOR FRANK GONZALEZ
 CALCULATED/DESIGNED BY ARTURO ARIAS
 CHECKED BY DAVID C. ARIAS
 REVISED BY AA
 DATE REVISED 9-2-15

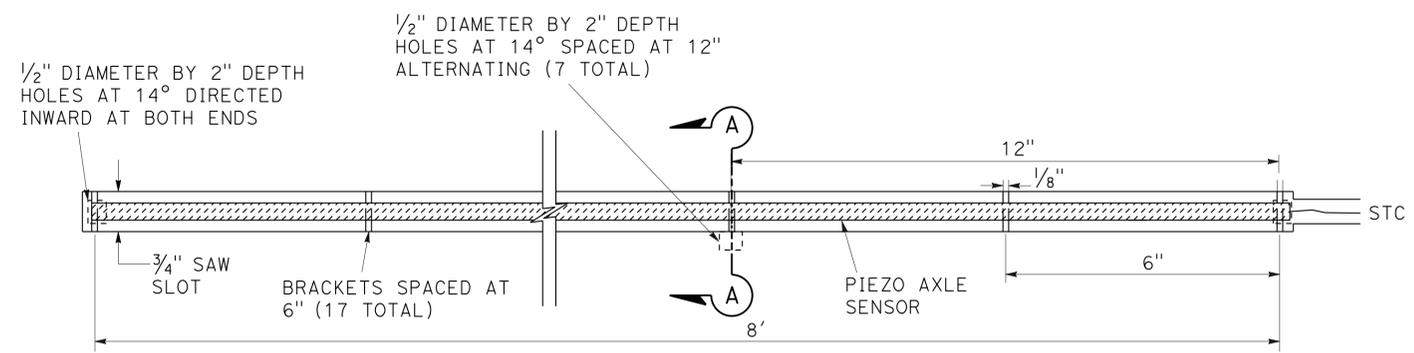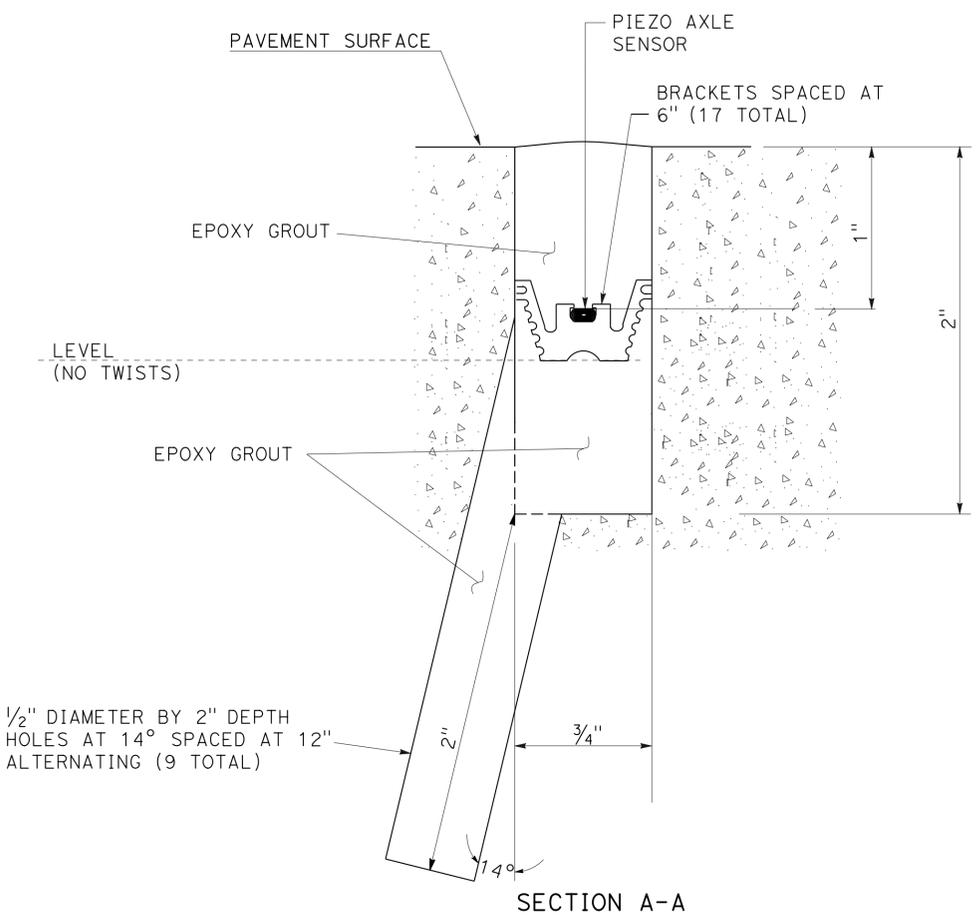



PIEZO AXLE SENSOR INSTALLATION

TOP VIEW
DETAIL A

**INDUCTIVE LOOP DETECTOR
SENSOR DESIGNATION**

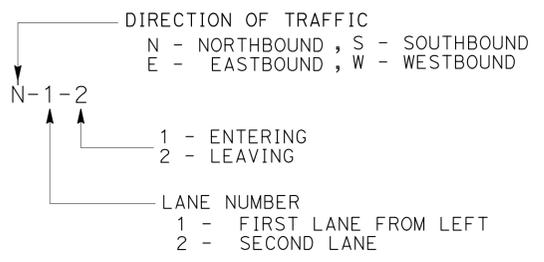

PIEZO AXLE SENSOR DESIGNATION

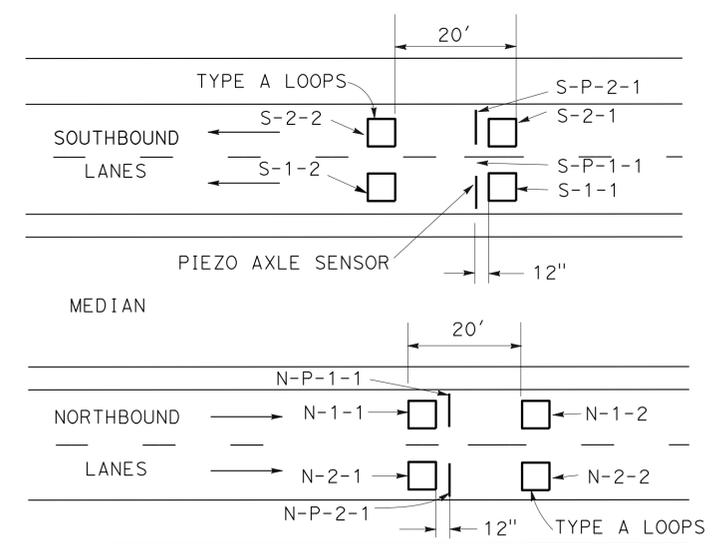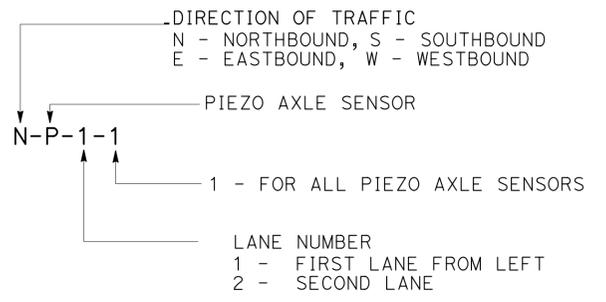

**LOOP DETECTOR AND PIEZO AXLE SENSOR
PLACEMENT AND DESIGNATION**

DETAIL B

**ELECTRICAL DETAILS
E-2**

NO SCALE

	M
Maint	MAINTENANCE
Max	MAXIMUM
MB	METAL BEAM
MBB	METAL BEAM BARRIER
MBGR	METAL BEAM GUARD RAILING
Med	MEDIAN
MGS	MIDWEST GUARDRAIL SYSTEM
MH	MANHOLE
Min	MINIMUM
Misc	MISCELLANEOUS
Misc I & S	MISCELLANEOUS IRON AND STEEL
Mkr	MARKER
Mod	MODIFIED, MODIFY
Mon	MONUMENT
MP	METAL PLATE
MPGR	METAL PLATE GUARD RAILING
MR	MOVEMENT RATING
MSE	MECHANICALLY STABILIZED EMBANKMENT
Mt	MOUNTAIN, MOUNT
MtI	MATERIAL
MVP	MAINTENANCE VEHICLE PULLOUT
	N
N	NORTH
NB	NORTHBOUND
No.	NUMBER (MUST HAVE PERIOD)
Nos.	NUMBERS (MUST HAVE PERIOD)
NPS	NOMINAL PIPE SIZE
NS	NEAR SIDE
NSP	NEW STANDARD PLAN
NTS	NOT TO SCALE
	O
Obir	OBLITERATE
OC	OVERCROSSING
OD	OUTSIDE DIAMETER
OF	OUTSIDE FACE
OG	ORIGINAL GROUND
OGAC	OPEN GRADED ASPHALT CONCRETE
OGFC	OPEN GRADED FRICTION COURSE
OH	OVERHEAD
OHWM	ORDINARY HIGH WATER MARK
O-O	OUT TO OUT
Opp	OPPOSITE
OSD	OVERSIDE DRAIN
	P
p	PAGE
PAP	PERFORATED ALUMINUM PIPE
PB	PULL BOX
PC	POINT OF CURVATURE, PRECAST
PCC	POINT OF COMPOUND CURVE, PORTLAND CEMENT CONCRETE
PCMS	PORTABLE CHANGEABLE MESSAGE SIGN
PCP	PERFORATED CONCRETE PIPE, PRESTRESSED CONCRETE PIPE
PCVC	POINT OF COMPOUND VERTICAL CURVE
PEC	PERMIT TO ENTER AND CONSTRUCT
Ped	PEDESTRIAN
Ped OC	PEDESTRIAN OVERCROSSING
Ped UC	PEDESTRIAN UNDERCROSSING
Perm MtI	PERMEABLE MATERIAL

	P continued
PG	PROFILE GRADE
PI	POINT OF INTERSECTION
PJP	PARTIAL JOINT PENETRATION
Pkwy	PARKWAY
PL, PL	PLATE
P/L	PROPERTY LINE
PM	POST MILE, TIME FROM NOON TO MIDNIGHT
PN	PAVING NOTCH
POC	POINT OF HORIZONTAL CURVE
POT	POINT OF TANGENT
POVC	POINT OF VERTICAL CURVE
PP	PIPE PILE, PLASTIC PIPE, POWER POLE
PPL	PREFORMED PERMEABLE LINER
PPP	PERFORATED PLASTIC PIPE
PRC	POINT OF REVERSE CURVE
PRF	PAVEMENT REINFORCING FABRIC
PRVC	POINT OF REVERSE VERTICAL CURVE
PS&E	PLANS, SPECIFICATIONS AND ESTIMATES
PS, P/S	PRESTRESSED
PSP	PERFORATED STEEL PIPE
PT	POINT OF TANGENCY
PVC	POLYVINYL CHLORIDE
Pvmt	PAVEMENT
	Q
Qty	QUANTITY
	R
R	RADIUS
R & D	REMOVE AND DISPOSE
R & S	REMOVE AND SALVAGE
R/C	RATE OF CHANGE
RCA	REINFORCED CONCRETE ARCH
RCB	REINFORCED CONCRETE BOX
RCP	REINFORCED CONCRETE PIPE
RCPA	REINFORCED CONCRETE PIPE ARCH
Rd	ROAD
Reinf	REINFORCED, REINFORCEMENT, REINFORCING
Rel	RELOCATE
Repl	REPLACEMENT
Ret	RETAINING
Rev	REVISED, REVISION
Rdwy	ROADWAY
RHMA	RUBBERIZED HOT MIX ASPHALT
Riv	RIVER
RM	ROAD-MIXED
RP	RADIUS POINT, REFERENCE POINT
RR	RAILROAD
RSP	ROCK SLOPE PROTECTION, REVISED STANDARD PLAN
Rt	RIGHT
Rte	ROUTE
RW	REDWOOD, RETAINING WALL
R/W	RIGHT OF WAY
Rwy	RAILWAY

	S
S	SOUTH, SUPPLEMENT
SAE	STRUCTURE APPROACH EMBANKMENT
Salv	SALVAGE
SAPP	STRUCTURAL ALUMINUM PLATE PIPE
SB	SOUTHBOUND
SC	SAND CUSHION
SCSP	SLOTTED CORRUGATED STEEL PIPE
SD	STORM DRAIN
Sec	SECOND, SECTION
Sep	SEPARATION
SG	SUBGRADE
Shld	SHOULDER
Sht	SHEET
Sim	SIMILAR
SL	STATION LINE
SM	SELECTED MATERIAL
Spec	SPECIAL, SPECIFICATIONS
SPP	SLOTTED PLASTIC PIPE
SS	SLOPE STAKE
SSBM	STRAP AND SADDLE BRACKET METHOD
SSD	STRUCTURAL SECTION DRAIN
SSPA	STRUCTURAL STEEL PLATE ARCH
SSPP	STRUCTURAL STEEL PLATE PIPE
SSPPA	STRUCTURAL STEEL PLATE PIPE ARCH
SSRP	STEEL SPIRAL RIB PIPE
St	STREET
Sta	STATION
STBB	SINGLE THRIE BEAM BARRIER
Std	STANDARD
Str	STRUCTURE
Surf	SURFACING
SW	SIDEWALK, SOUND WALL
Swr	SEWER
Sym	SYMMETRICAL
S4S	SURFACE 4 SIDES
	T
T	SEMI-TANGENT
Tan	TANGENT
TBB	THRIE BEAM BARRIER
Tbr	TIMBER
TC	TOP OF CURB
TCB	TRAFFIC CONTROL BOX
TCE	TEMPORARY CONSTRUCTION EASEMENT
TeI	TELEPHONE
Temp	TEMPORARY
TG	TOP OF GRADE
Tot	TOTAL
TP	TELEPHONE POLE
TPB	TREATED PERMEABLE BASE
TPM	TREATED PERMEABLE MATERIAL
Trans	TRANSITION

	T continued
TS	TRANSVERSE, TRAFFIC SIGNAL, TUBULAR STEEL
Typ	TYPICAL
	U
UC	UNDERCROSSING
UD	UNDERDRAIN
UG	UNDERGROUND
UON	UNLESS OTHERWISE NOTED
UP	UNDERPASS
	V
V	VALVE, DESIGN SPEED
Var	VARIABLE, VARIES
VC	VERTICAL CURVE
VCP	VITRIFIED CLAY PIPE
Vert	VERTICAL
Via	VIADUCT
Vol	VOLUME
	W
W	WEST, WIDTH
WB	WESTBOUND
WH	WEEP HOLE
WM	WIRE MESH
WS	WATER SURFACE
WSP	WELDED STEEL PIPE
Wt	WEIGHT
WV	WATER VALVE
WW	WINGWALL
WWL	WINGWALL LAYOUT LINE
	X
X Sec	CROSS SECTION
Xing	CROSSING
	Y
Yr	YEAR
Yrs	YEARS

Dist	COUNTY	ROUTE	POST MILES TOTAL PROJECT	SHEET No.	TOTAL SHEETS
06	Fre	33	11.1/14.8, 16.9/22.7	8	20

Grace M. Tsushima
REGISTERED CIVIL ENGINEER

July 19, 2013
PLANS APPROVAL DATE

REGISTERED PROFESSIONAL ENGINEER
 Grace M. Tsushima
 No. C49814
 Exp. 9-30-14
 CIVIL
 STATE OF CALIFORNIA

THE STATE OF CALIFORNIA OR ITS OFFICERS OR AGENTS SHALL NOT BE RESPONSIBLE FOR THE ACCURACY OR COMPLETENESS OF SCANNED COPIES OF THIS PLAN SHEET.

TO ACCOMPANY PLANS DATED 11-02-15

UNIT OF MEASUREMENT SYMBOLS:
Some of the symbols used in the project plan quantity tables and in the Bid Item List are:

TABLE A

SYMBOL USED	DEFINITIONS
ACRE	ACRE
CF	CUBIC FOOT
CY	CUBIC YARD
EA	EACH
GAL	GALLON
LB	POUND
LF	LINEAR FOOT
SQFT	SQUARE FOOT
SQYD	SQUARE YARD
STA	100 FEET
TAB	TABLET
TON	2,000 POUNDS

Some of the symbols used in the plans other than in the project plan quantity tables are:

TABLE B

SYMBOL USED	DEFINITIONS
ksi	KIPS PER SQUARE INCH
ksf	KIPS PER SQUARE FOOT
psi	POUNDS PER SQUARE INCH
psf	POUNDS PER SQUARE FOOT
lb/ft ³ , pcf	POUNDS PER CUBIC FOOT
tsf	TONS PER SQUARE FOOT
mph, MPH *	MILES PER HOUR
ø	NOMINAL DIAMETER
oz	OUNCE
lb	POUND
kip	1,000 POUNDS
cal	CALORIE
ft	FOOT OR FEET
gal	GALLON

* For use on a sign panel only

STATE OF CALIFORNIA
DEPARTMENT OF TRANSPORTATION

**ABBREVIATIONS
(SHEET 2 OF 2)**

NO SCALE

RSP A10B DATED JULY 19, 2013 SUPERSEDES STANDARD PLAN A10B
DATED MAY 20, 2011 - PAGE 2 OF THE STANDARD PLANS BOOK DATED 2010.


2010 REVISED STANDARD PLAN RSP A10B

Dist	COUNTY	ROUTE	POST MILES TOTAL PROJECT	SHEET No.	TOTAL SHEETS
06	Fre	33	11.1/14.8, 16.9/22.7	9	20


Roberto L. McLaughlin
 REGISTERED CIVIL ENGINEER
 April 20, 2012
 PLANS APPROVAL DATE
 THE STATE OF CALIFORNIA OR ITS OFFICERS OR AGENTS SHALL NOT BE RESPONSIBLE FOR THE ACCURACY OR COMPLETENESS OF SCANNED COPIES OF THIS PLAN SHEET.

REGISTERED PROFESSIONAL ENGINEER
 Roberto L. McLaughlin
 No. C40375
 Exp. 3-31-13
 CIVIL
 STATE OF CALIFORNIA


TO ACCOMPANY PLANS DATED 11-02-15

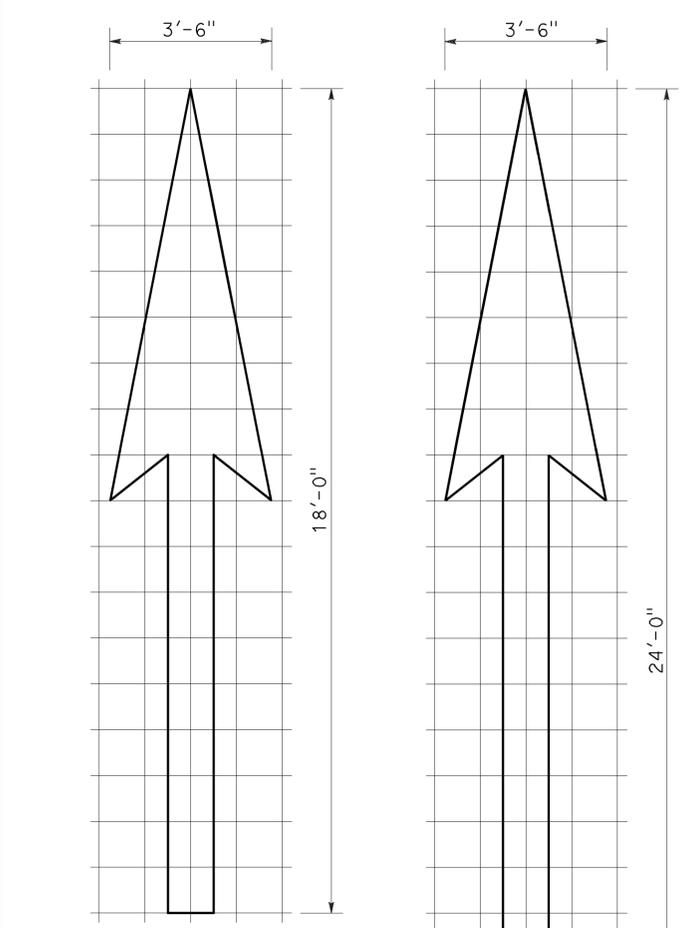


1'-0" GRID 1'-0"
A=25 ft²
TYPE I 18'-0" ARROW

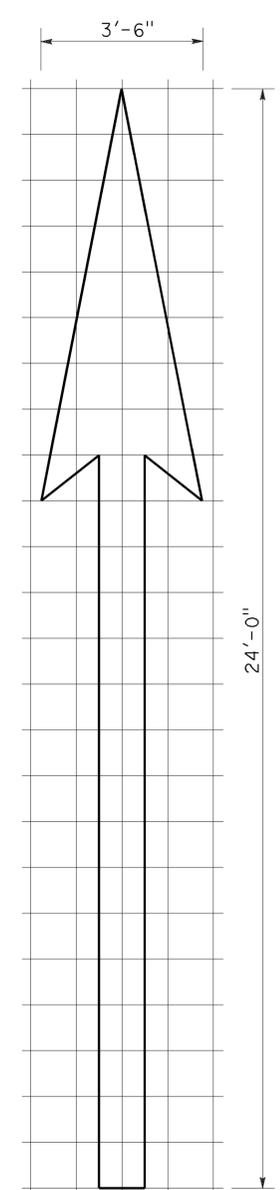


1'-0" GRID 1'-0"
A=31 ft²
TYPE I 24'-0" ARROW

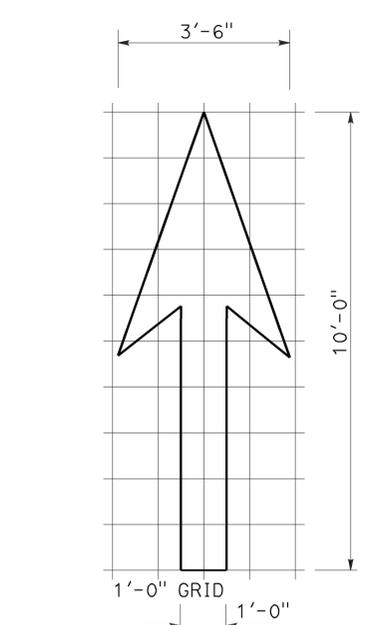


1'-0" GRID 1'-0"
A=14 ft²
TYPE I 10'-0" ARROW

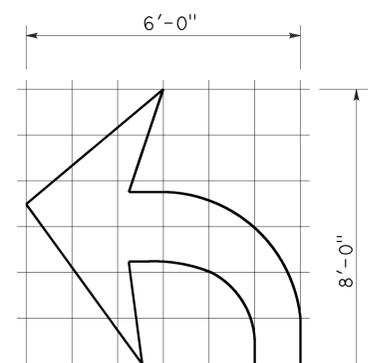


1'-0" GRID 1'-0"
A=15 ft²
TYPE IV (L) ARROW
(For Type IV (R) arrow, use mirror image)

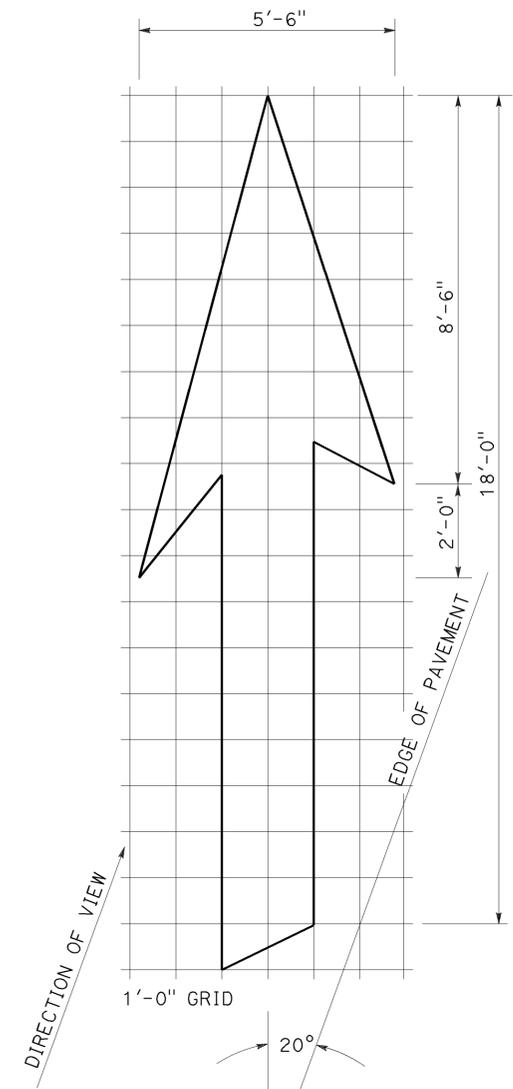


1'-0" GRID 20°
A=42 ft²
TYPE VI ARROW
Right lane drop arrow
(For left lane, use mirror image)

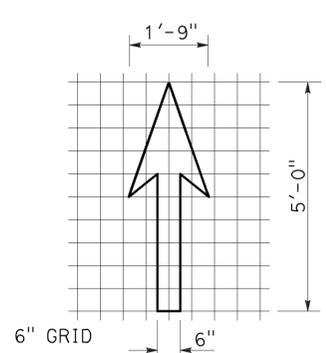


6" GRID 6"
A=3.5 ft²
BIKE LANE ARROW

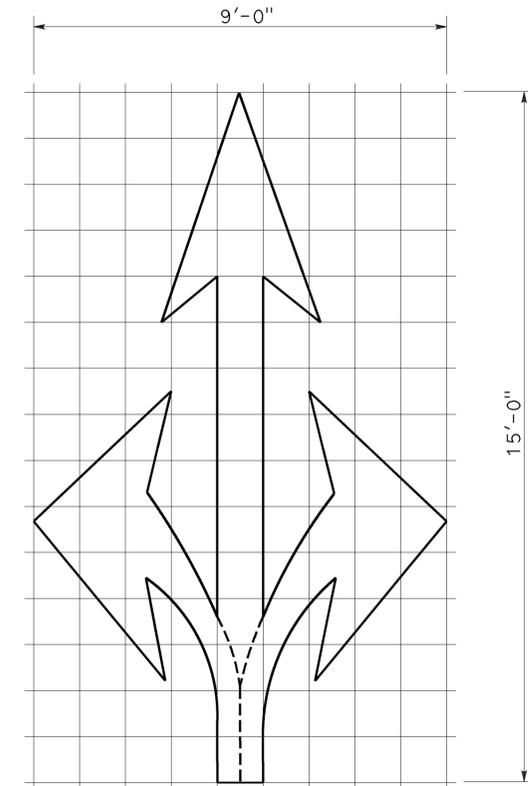

1'-0" GRID 1'-0"
A=36 ft²
TYPE VIII ARROW

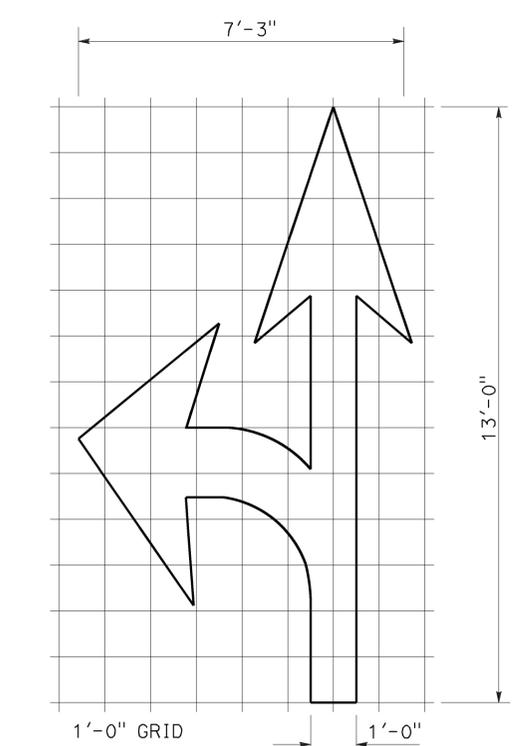

1'-0" GRID 1'-0"
A=27 ft²
TYPE VII (L) ARROW
(For Type VII (R) arrow, use mirror image)

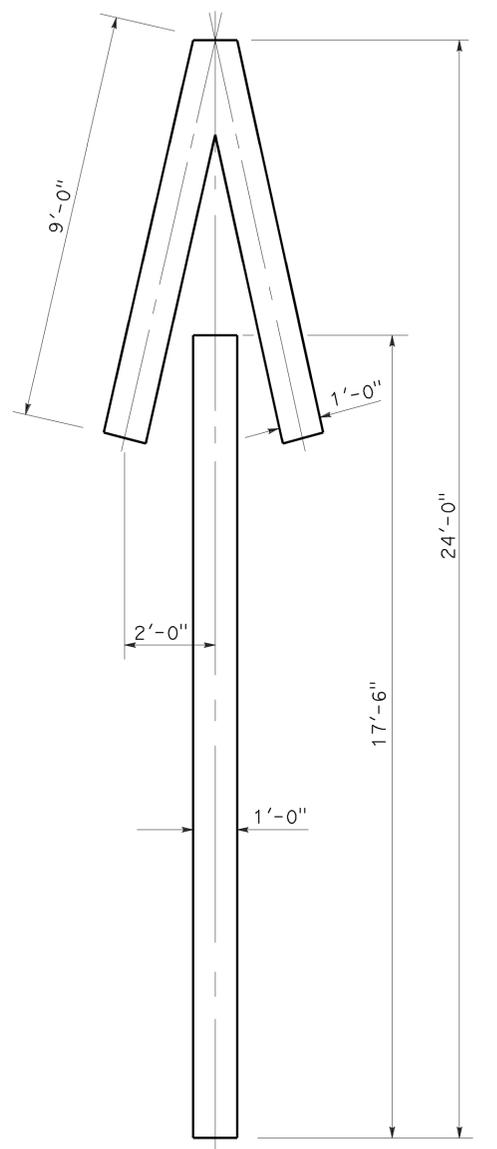

A=33 ft²
TYPE V ARROW

NOTE:
Minor variations in dimensions may be accepted by the Engineer.


STATE OF CALIFORNIA
DEPARTMENT OF TRANSPORTATION
**PAVEMENT MARKINGS
ARROWS**
NO SCALE

RSP A24A DATED APRIL 20, 2012 SUPERSEDES STANDARD PLAN A24A DATED MAY 20, 2011 - PAGE 13 OF THE STANDARD PLANS BOOK DATED 2010.


REVISED STANDARD PLAN RSP A24A

2010 REVISED STANDARD PLAN RSP A24A


TO ACCOMPANY PLANS DATED 11-02-15

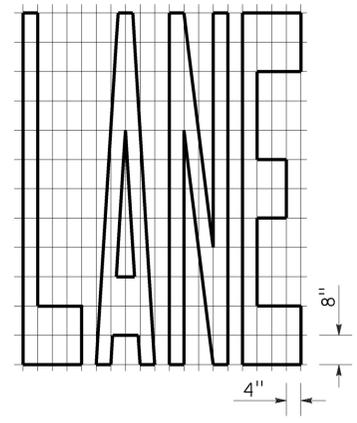


A=24 ft²

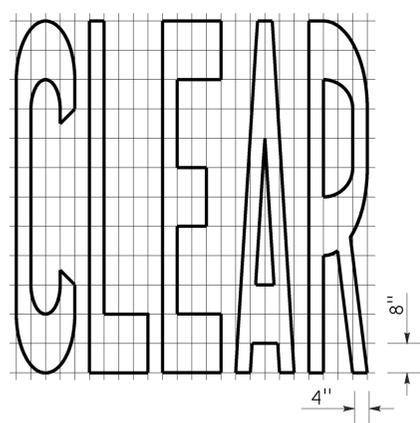


A=27 ft²

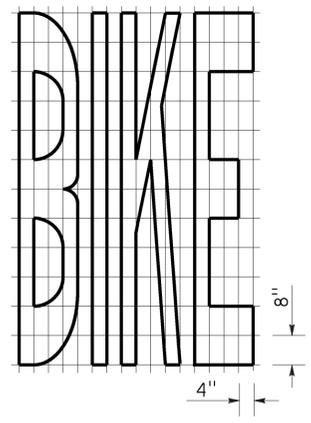


A=21 ft²

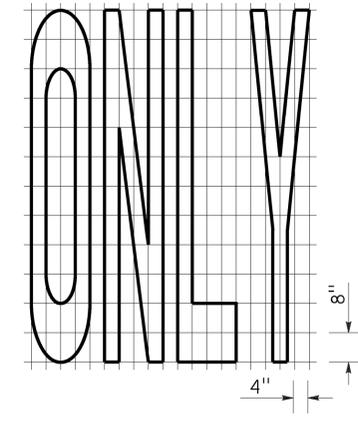


A=22 ft²

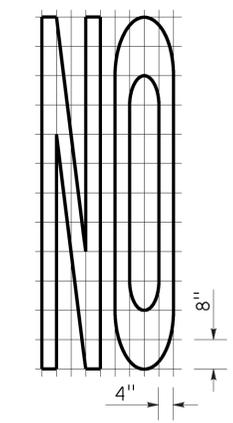


A=14 ft²

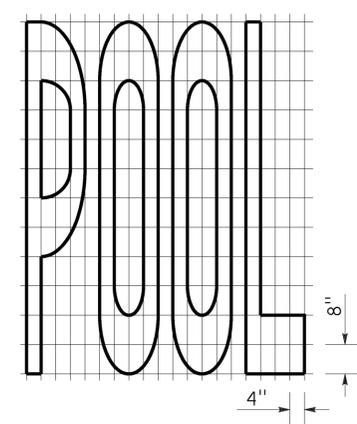


A=23 ft²

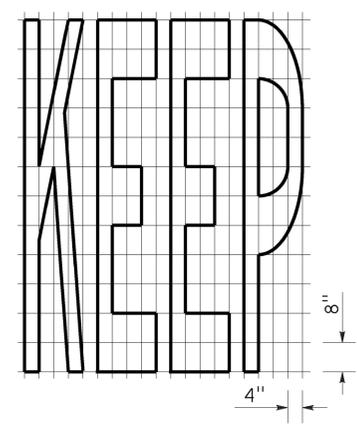


A=24 ft²

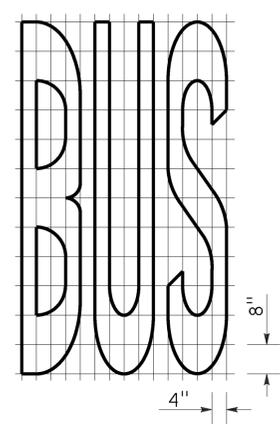

A=20 ft²

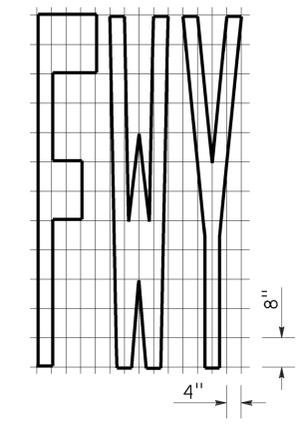


A=16 ft²

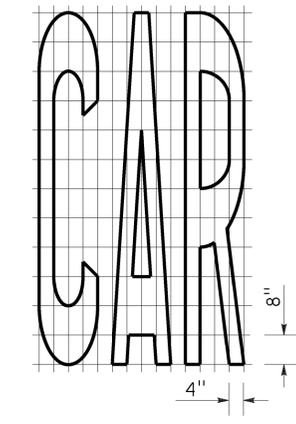


A=17 ft²


WORD MARKINGS			
ITEM	ft ²	ITEM	ft ²
LANE	24	NO	14
POOL	23	BIKE	21
CAR	17	BUS	20
CLEAR	27	ONLY	22
KEEP	24	FWY	16

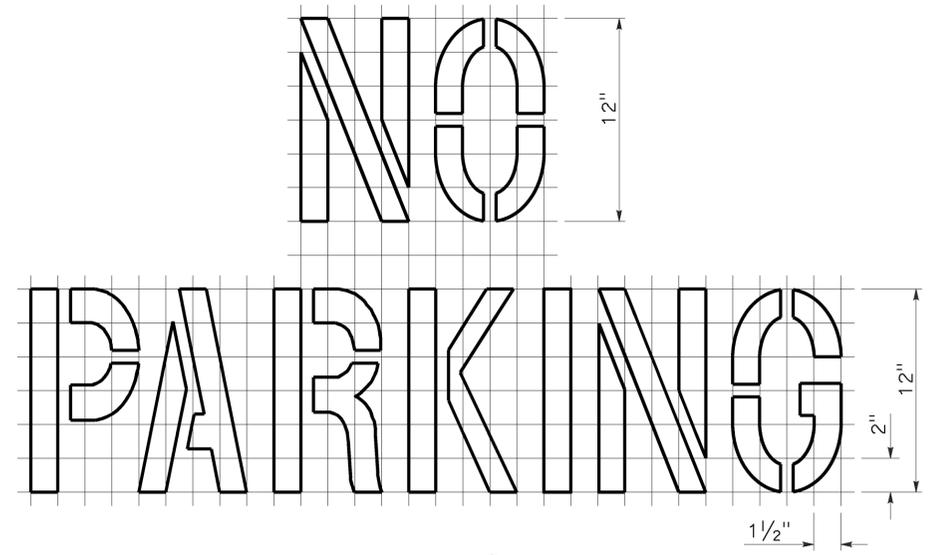

A=2 ft²
See Notes 6 and 7

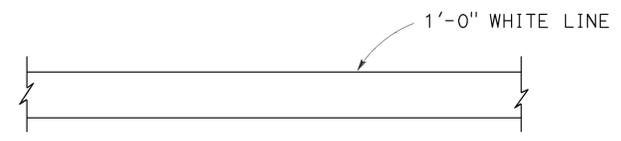

LIMIT LINE (STOP LINE)

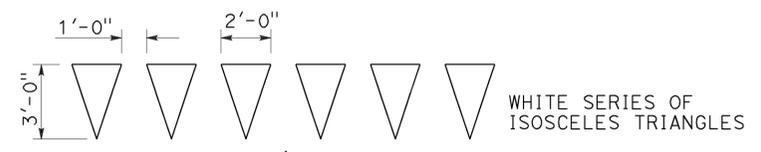

YIELD LINE

NOTES:

- If a message consists of more than one word, it should read "UP", i.e., the first word should be nearest the driver.
- The space between words should be at least four times the height of the characters for low speed roads, but not more than ten times the height of the characters. The space may be reduced appropriately where there is limited space because of local conditions.
- Minor variations in dimensions may be accepted by the Engineer.
- Portions of a letter, number or symbol may be separated by connecting segments not to exceed 2" in width.
- The words "NO PARKING" pavement marking is to be used for parking facilities. For typical locations of markings, see Standard Plans A90A and A90B.
- The words "NO PARKING", shall be painted in white letters no less than 1'-0" high on a contrasting background and located so that it is visible to traffic enforcement officials.

STATE OF CALIFORNIA
 DEPARTMENT OF TRANSPORTATION
**PAVEMENT MARKINGS
 WORDS, LIMIT AND YIELD LINES**
 NO SCALE

RSP A24E DATED JULY 20, 2012 SUPERSEDES STANDARD PLAN A24E
 DATED MAY 20, 2011 - PAGE 17 OF THE STANDARD PLANS BOOK DATED 2010.

TO ACCOMPANY PLANS DATED 11-02-15

TABLE 1

TAPER LENGTH CRITERIA AND CHANNELIZING DEVICE SPACING							
SPEED (S)	MINIMUM TAPER LENGTH * FOR WIDTH OF OFFSET 12 FEET (W)				MAXIMUM CHANNELIZING DEVICE SPACING		
	TANGENT 2L	MERGING L	SHIFTING L/2	SHOULDER L/3	X	Y	Z **
					TAPER	TANGENT	CONFLICT
mph	ft	ft	ft	ft	ft	ft	ft
20	160	80	40	27	20	40	10
25	250	125	63	42	25	50	12
30	360	180	90	60	30	60	15
35	490	245	123	82	35	70	17
40	640	320	160	107	40	80	20
45	1080	540	270	180	45	90	22
50	1200	600	300	200	50	100	25
55	1320	660	330	220	55	110	27
60	1440	720	360	240	60	120	30
65	1560	780	390	260	65	130	32
70	1680	840	420	280	70	140	35

* - For other offsets, use the following merging taper length formula for L:
 For speed of 40 mph or less, $L = WS^2/60$
 For speed of 45 mph or more, $L = WS$

Where: L = Taper length in feet
 W = Width of offset in feet
 S = Posted speed limit, off-peak 85th-percentile speed prior to work starting, or the anticipated operating speed in mph

** - Use for taper and tangent sections where there are no pavement markings or where there is a conflict between existing pavement markings and channelizers (CA).

TABLE 2

LONGITUDINAL BUFFER SPACE AND FLAGGER STATION SPACING				
SPEED *	Min D **	DOWNGRADE Min D ***		
		-3%	-6%	-9%
		ft	ft	ft
20	115	116	120	126
25	155	158	165	173
30	200	205	215	227
35	250	257	271	287
40	305	315	333	354
45	360	378	400	427
50	425	446	474	507
55	495	520	553	593
60	570	598	638	686
65	645	682	728	785
70	730	771	825	891

* - Speed is posted speed limit, off-peak 85th-percentile speed prior to work starting, or the anticipated operating speed in mph
 ** - Longitudinal buffer space or flagger station spacing
 *** - Use on sustained downgrade steeper than -3 percent and longer than 1 mile.

TABLE 3

ADVANCE WARNING SIGN SPACING			
ROAD TYPE	DISTANCE BETWEEN SIGNS *		
	A	B	C
	ft	ft	ft
URBAN - 25 mph OR LESS	100	100	100
URBAN - MORE THAN 25 mph TO 40 mph	250	250	250
URBAN - MORE THAN 40 mph	350	350	350
RURAL	500	500	500
EXPRESSWAY / FREEWAY	1000	1500	2640

* - The distances are approximate, are intended for guidance purposes only, and should be applied with engineering judgment. These distances should be adjusted by the Engineer for field conditions, if necessary, by increasing or decreasing the recommended distances.

STATE OF CALIFORNIA
 DEPARTMENT OF TRANSPORTATION
**TRAFFIC CONTROL SYSTEM TABLES
 FOR LANE AND RAMP CLOSURES**
 NO SCALE

RSP T9 DATED JULY 19, 2013 SUPERSEDES RSP T9 DATED APRIL 19, 2013 THAT SUPPLEMENTS THE STANDARD PLANS BOOK DATED 2010.

NOTES:

See Revised Standard Plan RSP T9 for tables.

Use cone spacing X for taper segment, Y for tangent segment or Z for conflict situations, as appropriate, per Table 1, unless X, Y, or Z cone spacing is shown on this sheet.

Unless otherwise specified in the special provisions, all temporary warning signs shall have black legend on fluorescent orange background.

California codes are designated by (CA). Otherwise, Federal (MUTCD) codes are shown.

Dist	COUNTY	ROUTE	POST MILES TOTAL PROJECT	SHEET No.	TOTAL SHEETS
06	Fre	33	11.1/14.8, 16.9/22.7	12	20


Devinder Singh
 REGISTERED CIVIL ENGINEER
 No. C50470
 Exp. 6-30-17
 CIVIL
 STATE OF CALIFORNIA

October 30, 2015
 PLANS APPROVAL DATE

THE STATE OF CALIFORNIA OR ITS OFFICERS OR AGENTS SHALL NOT BE RESPONSIBLE FOR THE ACCURACY OR COMPLETENESS OF SCANNED COPIES OF THIS PLAN SHEET.

TYPICAL LANE CLOSURE WITH REVERSIBLE CONTROL

TO ACCOMPANY PLANS DATED 11-02-15

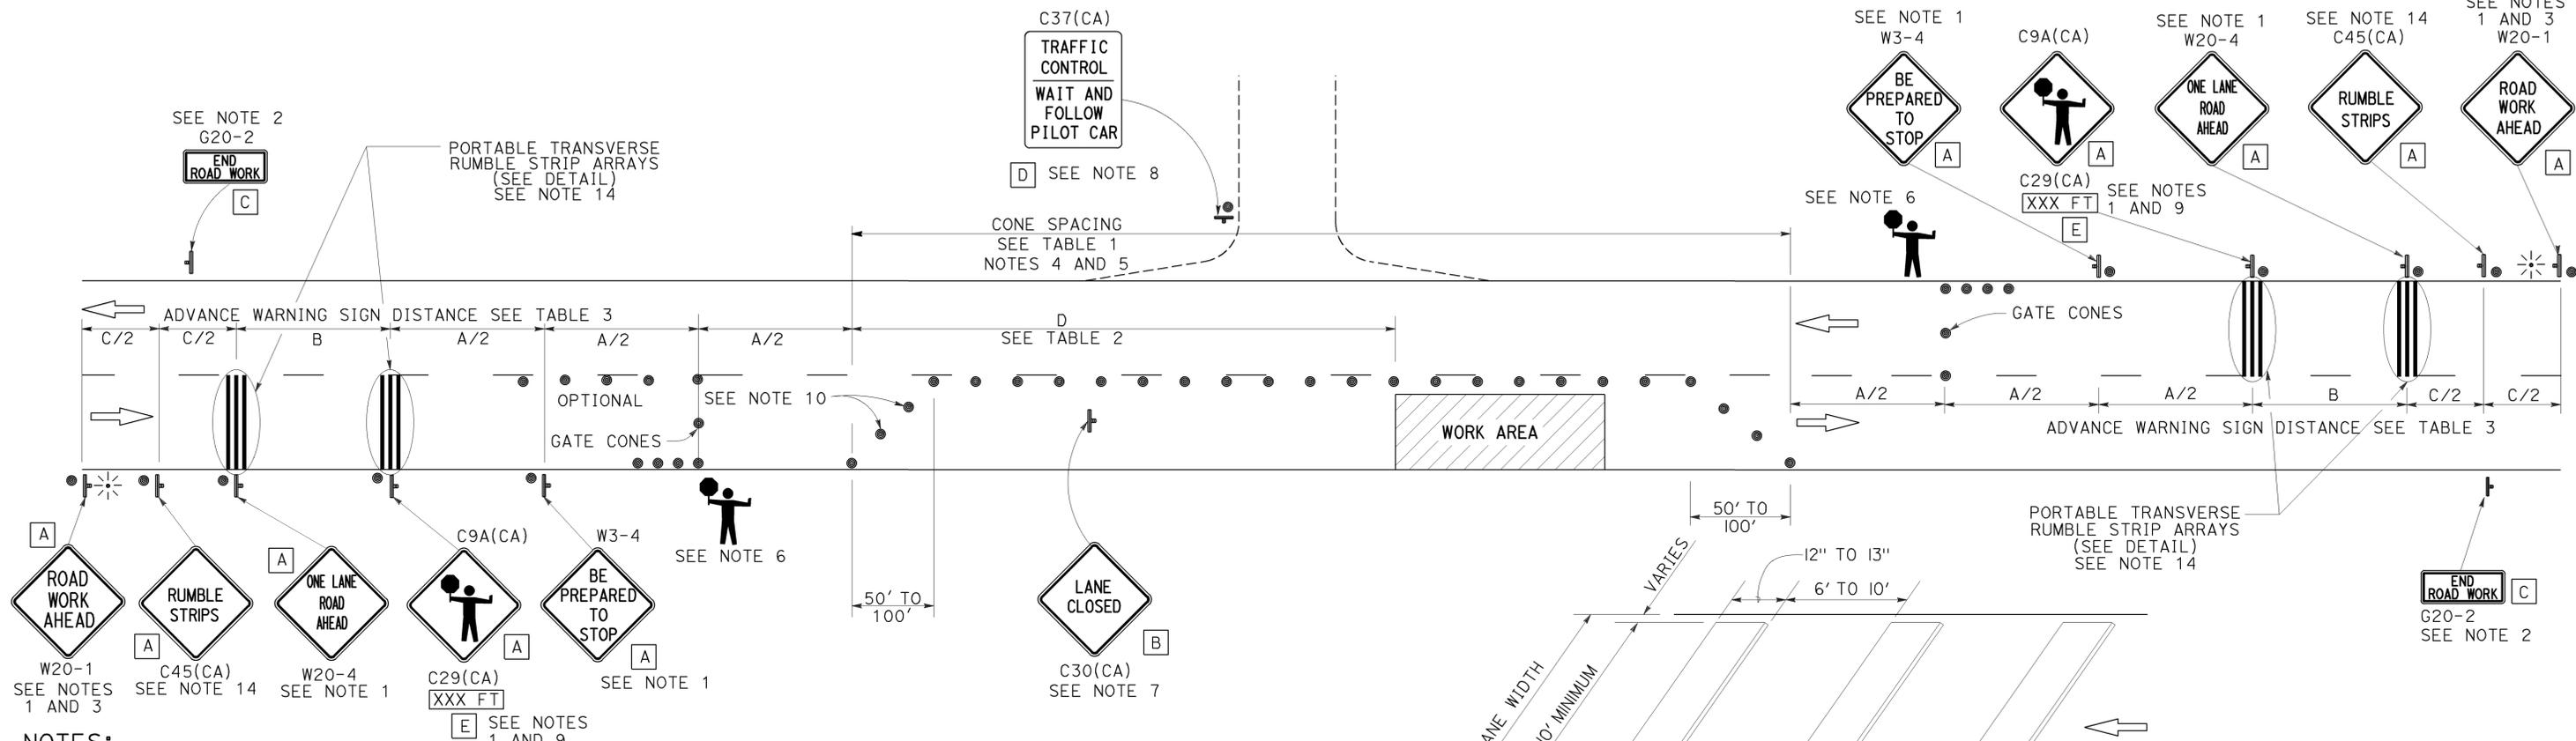

NOTES:

- Each advance warning sign in each direction of travel shall be equipped with at least two flags for daytime closure. Each flag shall be at least 16" x 16" in size and shall be orange or fluorescent red-orange in color. Flashing beacons shall be placed at the locations indicated for lane closure during hours of darkness.
- A G20-2 "END ROAD WORK" sign, as appropriate, shall be placed at the end of the lane control unless the end of work area is obvious, or ends within a larger project's limits.
- If the W20-1 sign would follow within 2000' of a stationary W20-1 or G20-1 "ROAD WORK NEXT _____ MILES", use a W20-4 sign for the first advance warning sign.
- All cones used for lane closures during the hours of darkness shall be fitted with retroreflective bands (or sleeves) as specified in the specifications.
- Portable delineators, placed at one-half the spacing indicated for traffic cones, may be used instead of cones for daytime closures only.
- Additional advance flaggers may be required. Flagger should stand in a conspicuous place, be visible to approaching traffic as well as approaching vehicles after the first vehicle has stopped. During the hours of darkness, the flagging-station and flagger shall be illuminated and clearly visible to approaching traffic. The illumination footprint of the lighting on the ground shall be at least 20' in diameter. Place a minimum of four cones at 50' intervals in advance of flagger station as shown.
- Place C30(CA) "LANE CLOSED" sign at 500' to 1000' intervals throughout extended work areas. They are optional if the work area is visible from the flagger station.
- When a pilot car is used, place a C37(CA) "TRAFFIC CONTROL-WAIT AND FOLLOW PILOT CAR" sign with black legend on white background at all intersections, driveways and alleys without a flagger within traffic control area. Signs shall be clean and visible at all times. Where traffic can not be effectively self-regulated, at least one flagger shall be used at each intersection within traffic control area.
- An optional C29(CA) sign may be placed below the C9A(CA) sign.
- Either traffic cones or barricades shall be placed on the taper. Barricades shall be Type I, II, or III.
- The color of the portable transverse rumble strips shall be black or orange. Use 2 arrays, each array shall consist of 3 rumble strips.
- Portable transverse rumble strips shall not be placed on sharp horizontal or vertical curves nor shall they be placed through pedestrian crossings.
- If the portable transverse rumble strips become out of alignment (skewed) by more than 6 inches, measured from one end to the other, they shall be readjusted to bring the placement back to the original location.
- Portable transverse rumble strips are not required if any one of the following conditions is satisfied:
 - Work duration occupies a location for four hours or less
 - Posted speed limit is below 45 MPH
 - Work is of emergency nature
 - Work zone is in snow or icy weather conditions

LEGEND

- TRAFFIC CONE
- ⊥ TEMPORARY TRAFFIC CONTROL SIGN
- ⚡ PORTABLE FLASHING BEACON
- 🚧 FLAGGER

SIGN PANEL SIZE (Min)

- A 48" x 48"
- B 30" x 30"
- C 36" x 18"
- D 36" x 42"
- E 20" x 7"

TRAFFIC CONTROL SYSTEM FOR LANE CLOSURE ON TWO LANE CONVENTIONAL HIGHWAYS


NO SCALE

RSP T13 DATED OCTOBER 30, 2015 SUPERSEDES
 RSP T13 DATED OCTOBER 17, 2014, RSP T13 DATED JULY 18, 2014
 AND RSP T13 DATED APRIL 19, 2013 AND STANDARD PLAN T13 DATED
 MAY 20, 2011 - PAGE 241 OF THE STANDARD PLANS BOOK DATED 2010.

REVISED STANDARD PLAN RSP T13

2010 REVISED STANDARD PLAN RSP T13

TO ACCOMPANY PLANS DATED 11-02-15

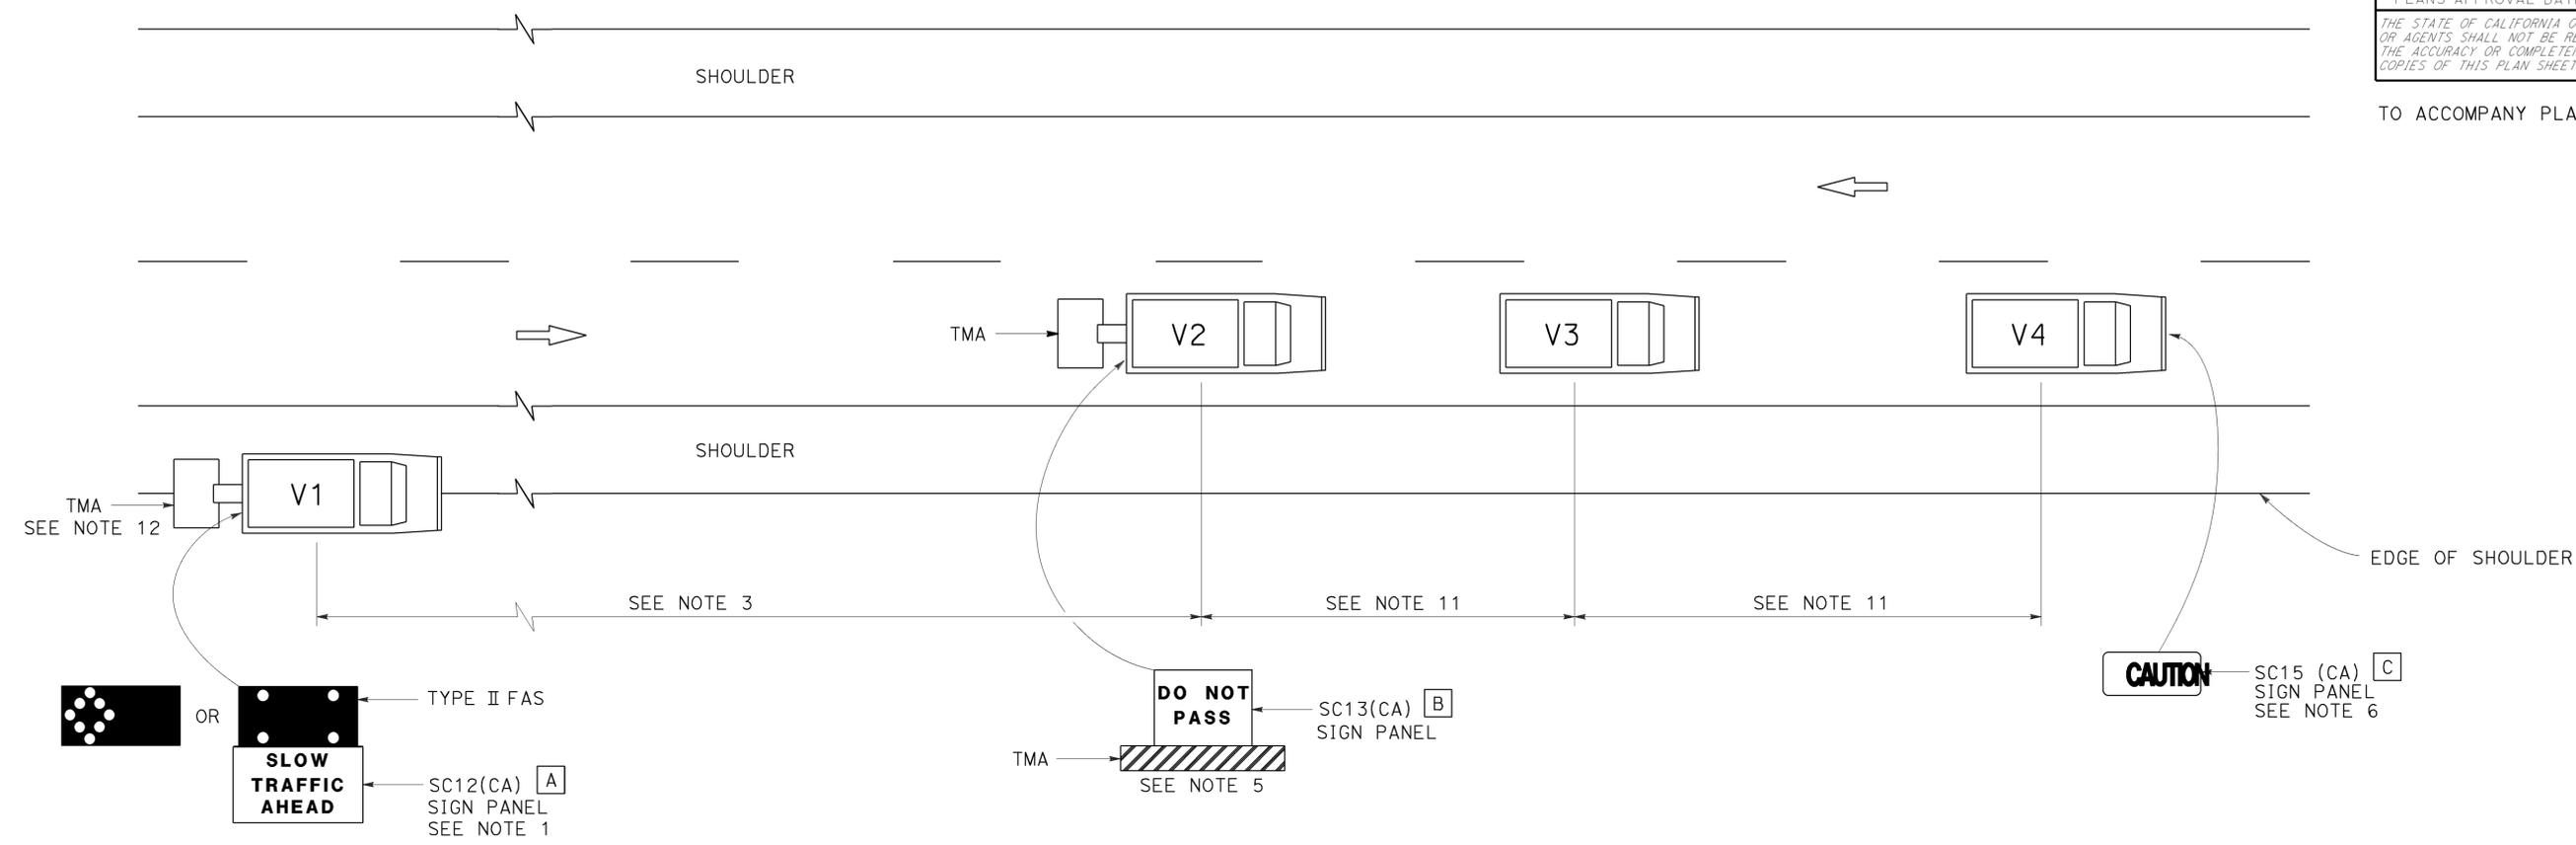

NOTES:

1. Either a changeable message sign or a SC12(CA) "SLOW TRAFFIC AHEAD" sign shall be mounted on the rear of sign vehicle V1. The changeable message sign shall be sequenced to show the "CAUTION" message first, follow by the "SLOW TRAFFIC AHEAD" message. A Type II flashing arrow sign may be used with the SC12(CA) sign panel.
2. Sign vehicle V1 should be positioned where highly visible when shoulders are not available.
3. If traffic queues develop, sign vehicle V1 should be positioned upstream from the end of queue.
4. Vehicle-mounted sign panels shall have Type III or above retroreflective sheeting, black on white, or black on fluorescent orange, with 6" minimum series D letters per Caltrans sign specifications.
5. Shadow vehicle shall be equipped with a truck-mounted attenuator. The sign panel shown shall be mounted on the rear of shadow vehicle V2. The message "LANE CLOSED" may be used in place of the "DO NOT PASS" message.
6. The sign panel shown shall be mounted on the front of sign vehicle V4, facing opposing traffic.
7. All vehicles shall be equipped with flashing or rotating amber lights.
8. Sign vehicle V4 will not be required when the work and vehicles V2 and V3 are 2' or more from the centerline of the highway during the work or application operations.
9. All vehicles used for lane closures shall be equipped with two-way radios and the vehicle operators shall maintain communication during the work or application operation.
10. This plan shall not be used where workers would be on foot in the work area. Use a stationary type lane closure (Revised Standard Plan T13) for this condition.
11. Minimize spacing between vehicles V2 and V3 and vehicles V3 and V4 to deter road users from driving in between them.
12. If sign vehicle V1 encroaches into the traffic lane due to insufficient shoulder width, sign vehicle V1 shall be equipped with a truck-mounted attenuator. Sign vehicle V1 shall stay as close to the edge of shoulder as practicable.

LEGEND

- V1 SIGN VEHICLE
- V2 SHADOW VEHICLE
- V3 WORK/APPLICATION VEHICLE
- V4 SIGN VEHICLE
- TMA TRUCK-MOUNTED ATTENUATOR
- FLASHING ARROW SIGN (FAS) IN FLASHING CAUTION MODE
- FLASHING ARROW SIGN (FAS) IN ALTERNATING DIAMOND CAUTION

SIGN PANEL SIZE (Min)

- A** 72" x 42"
- B** 54" x 42"
- C** 54" x 24"

STATE OF CALIFORNIA
 DEPARTMENT OF TRANSPORTATION
**TRAFFIC CONTROL SYSTEM
 FOR MOVING LANE CLOSURE
 ON TWO LANE HIGHWAYS**
 NO SCALE

RSP T17 DATED APRIL 19, 2013 SUPERSEDES STANDARD PLAN T17
 DATED MAY 20, 2011 - PAGE 245 OF THE STANDARD PLANS BOOK DATED 2010.

REVISED STANDARD PLAN RSP T17

2010 REVISED STANDARD PLAN RSP T17

LEGEND:

AB	ABANDON. IF APPLIED TO CONDUIT, REMOVE CONDUCTORS
BC	INSTALL PULL BOX IN EXISTING CONDUIT RUN
BP	PEDESTRIAN BARRICADE, TYPE AS INDICATED ON PLAN
CB	INSTALL CONDUIT INTO EXISTING PULL BOX
CC	CONNECT NEW AND EXISTING CONDUIT. REMOVE EXISTING CONDUCTORS AND INSTALL CONDUCTORS AS INDICATED
CF	CONDUIT TO REMAIN FOR FUTURE USE. REMOVE CONDUCTORS. INSTALL PULL TAPE
DH	DETECTOR HANDHOLE
FA	FOUNDATION TO BE ABANDONED
IS	INSTALL SIGN ON SIGNAL MAST ARM
NS	NO SLIP BASE ON STANDARD
PEC	PHOTOELECTRIC CONTROL
PEU	PHOTOELECTRIC UNIT
RC	EQUIPMENT OR MATERIAL TO BE REMOVED AND BECOME THE PROPERTY OF THE CONTRACTOR
RE	REMOVE ELECTROLIER, FUSES AND BALLAST. TAPE ENDS OF CONDUCTORS
RL	RELOCATE EQUIPMENT
RR	REMOVE AND REUSE EQUIPMENT
RS	REMOVE AND SALVAGE EQUIPMENT
SC	SPLICE NEW TO EXISTING CONDUCTORS
SD	SERVICE DISCONNECT
TSP	TELEPHONE SERVICE POINT

ABBREVIATIONS

AC+	UNDERGROUNDED CONDUCTOR	MAT	MAST ARM MOUNTING TOP ATTACHMENT
APS	ACCESSIBLE PEDESTRIAN SIGNAL	MAS	MAST ARM MOUNTING SIDE ATTACHMENT
Batt	BATTERY	MBPS	MANUAL BYPASS SWITCH
BBS	BATTERY BACKUP SYSTEM	M/M	MULTIPLE TO MULTIPLE TRANSFORMER
BC	BOLT CIRCLE	Mtg	MOUNTING
BIK	BLACK	MV	MERCURY VAPOR LIGHTING FIXTURE
BP	BYPASS	MVDS	MICROWAVE VEHICLE DETECTION SYSTEM
BPB	BICYCLE PUSH BUTTON	N	NEUTRAL (GROUNDED CONDUCTOR)
C	CONDUIT	NB	NEUTRAL BUS
CB	CIRCUIT BREAKER	NC	NORMALLY CLOSE
CCTV	CLOSED CIRCUIT TELEVISION	NO	NORMALLY OPEN
Ckt	CIRCUIT	P	CIRCUIT BREAKER'S POLE
CMS	CHANGEABLE MESSAGE SIGN	PB	PULL BOX
Ctid	CALTRANS IDENTIFICATION	PBA	PUSH BUTTON ASSEMBLY
Comm	COMMUNICATION	PEC	PHOTOELECTRIC CONTROL
Cntl	CONTROL	Ped	PEDESTRIAN
DF	DEPARTMENT-FURNISHED	PEU	PHOTOELECTRIC UNIT
DLC	LOOP DETECTOR LEAD-IN CABLE	PT	CONDUIT WITH PULL TAPE
EMS	EXTINGUISHABLE MESSAGE SIGN	PTR	POWER TRANSFER RELAY
EVUC	EMERGENCY VEHICLE UNIT CABLE	RE	RELOCATED EQUIPMENT
EVUD	EMERGENCY VEHICLE UNIT DETECTOR	RM	RAMP METERING
FB	FLASHING BEACON	RWIS	ROADSIDE WEATHER INFORMATION SYSTEM
FBCA	FLASHING BEACON CONTROL ASSEMBLY	SB	SLIP BASE
FBS	FLASHING BEACON WITH SLIP BASE	SIC	SIGNAL INTERCONNECT CABLE
FO	FIBER OPTIC	Sig	SIGNAL
G	EQUIPMENT GROUNDING CONDUCTOR	SMA	SIGNAL MAST ARM
GB	GROUND BUS	SNS	STREET NAME SIGN
GFCI	GROUND FAULT CIRCUIT INTERRUPTER	SP	SERVICE POINT
Grn	GREEN	TB	TERMINAL BOARD
HAR	HIGHWAY ADVISORY RADIO	TDC	TELEPHONE DEMARCATION CABINET
Hex	HEXAGONAL	Temp	TEMPERATURE
HPS	HIGH PRESSURE SODIUM	TMS	TRAFFIC MONITORING STATION
IISNS	INTERNALLY ILLUMINATED STREET NAME SIGN	TOS	TRAFFIC OPERATIONS SYSTEM
ISL	INDUCTION SIGN LIGHTING	UPS	UNINTERRUPTABLE POWER SUPPLY
LED	LIGHT EMITTING DIODE	UPSC	UNINTERRUPTABLE POWER SUPPLY CONTROLLER
LMA	LUMINAIRE MAST ARM	Veh	VEHICLE
LPS	LOW PRESSURE SODIUM	VIVDS	VIDEO IMAGE VEHICLE DETECTION SYSTEM
Ltg	LIGHTING	Wht	WHITE
Lum	LUMINAIRE	WIM	WEIGH-IN-MOTION
M	METERED	Xfmr	TRANSFORMER

Dist	COUNTY	ROUTE	POST MILES TOTAL PROJECT	SHEET No.	TOTAL SHEETS
06	Fre	33	11.1/14.8, 16.9/22.7	14	20

Theresa Gabriel
REGISTERED ELECTRICAL ENGINEER

October 30, 2015
PLANS APPROVAL DATE

Theresa Aziz Gabriel
No. E15129
Exp. 6-30-16
ELECTRICAL

THE STATE OF CALIFORNIA OR ITS OFFICERS OR AGENTS SHALL NOT BE RESPONSIBLE FOR THE ACCURACY OR COMPLETENESS OF SCANNED COPIES OF THIS PLAN SHEET.

TO ACCOMPANY PLANS DATED 11-02-15

SOFFIT AND WALL-MOUNTED LUMINAIRES

- PENDANT SOFFIT LUMINAIRE, 70 W HPS UNLESS OTHERWISE SPECIFIED
- FLUSH-MOUNTED SOFFIT LUMINAIRE, 70 W HPS UNLESS OTHERWISE SPECIFIED
- WALL-MOUNTED LUMINAIRE, 70 W HPS UNLESS OTHERWISE SPECIFIED
- EXISTING SOFFIT OR WALL-MOUNTED LUMINAIRE TO REMAIN UNMODIFIED
- EXISTING SOFFIT OR WALL-MOUNTED LUMINAIRE TO BE MODIFIED AS SPECIFIED

NOTE:
Arrow indicates "street side" of luminaire.

COMMONLY USED SYMBOLS FOR UNITED STATES CUSTOMARY UNITS OF MEASUREMENT:

SYMBOL	DEFINITIONS
Ω	OHMS
min	MINUTE
s	SECOND
bps	BITS PER SECOND
Bps	BYTES PER SECOND
A	AMPERE
V	VOLT
V(ac)	VOLT (DIRECT CURRENT)
V(ac)	VOLT (ALTERNATING CURRENT)
FC	FOOT - CANDLE
W	WATTS
VA	VOLT-AMPERE
M	MEGA
k	KILO
m	MILLI
μ	MICRO
P	PICO
Hz	HERTZ

STATE OF CALIFORNIA
DEPARTMENT OF TRANSPORTATION

ELECTRICAL SYSTEMS (LEGEND AND ABBREVIATIONS)

NO SCALE

RSP ES-1A DATED OCTOBER 30, 2015 SUPERSEDES RSP ES-1A DATED JULY 19, 2013 AND STANDARD PLAN ES-1A DATED MAY 20, 2011 - PAGE 425 OF THE STANDARD PLANS BOOK DATED 2010.

REVISED STANDARD PLAN RSP ES-1A

MISCELLANEOUS ELECTROLIERS

NEW	EXISTING	
		LUMINAIRE ON WOOD POLE
		NON-STANDARD ELECTROLIER (SEE PROJECT LEGEND)
		CITY ELECTROLIER
		ELECTROLIER FOUNDATION (FUTURE INSTALLATION)

- NOTES:**
- LED luminaires shall be 235 W when installed on Type 21, 21D, 30, 31 and 32 Standards, unless otherwise specified. LED luminaires shall be 165 W when installed on other type standards or poles, unless otherwise specified.
 - Luminaires shall be the cutoff type, ANSI Type III medium cutoff lighting distribution, unless otherwise specified.

STANDARD ELECTROLIER

NEW	EXISTING	STANDARD TYPE
		15
		15D
		15 STRUCTURE
		15D STRUCTURE
		21
		21D
		21 STRUCTURE
		21D STRUCTURE
		30
		31
		32

2010 REVISED STANDARD PLAN RSP ES-1A

Dist	COUNTY	ROUTE	POST MILES TOTAL PROJECT	SHEET No.	TOTAL SHEETS
06	Fre	33	11.1/14.8, 16.9/22.7	15	20

Theresa Gabriel
 REGISTERED ELECTRICAL ENGINEER
 October 30, 2015
 PLANS APPROVAL DATE
THE STATE OF CALIFORNIA OR ITS OFFICERS OR AGENTS SHALL NOT BE RESPONSIBLE FOR THE ACCURACY OR COMPLETENESS OF SCANNED COPIES OF THIS PLAN SHEET.

TO ACCOMPANY PLANS DATED 11-02-15

CONDUIT

NEW	EXISTING	
		LIGHTING CONDUIT, UNLESS OTHERWISE INDICATED OR NOTED
		TRAFFIC SIGNAL CONDUIT
		COMMUNICATION CONDUIT
		TELEPHONE CONDUIT
		FIRE ALARM CONDUIT
		FIBER OPTIC CONDUIT
		CONDUIT TERMINATION
		CONDUIT RISER ATTACHED TO THE STRUCTURE OR SERVICE POLE

SIGNAL EQUIPMENT

NEW	EXISTING	
		PEDESTRIAN SIGNAL HEAD
		PUSH BUTTON ASSEMBLY POST
		PEDESTRIAN BARRICADE
		VEHICLE SIGNAL HEAD (WITH BACKPLATE AND 3-SECTIONS: RED, YELLOW AND GREEN)
		VEHICLE SIGNAL HEAD WITH ANGLE VISOR
		MODIFICATIONS OF BASIC SYMBOL: "L" INDICATES ALL NON-ARROW SECTIONS LOUVERED "LG" INDICATES LOUVERED GREEN SECTION ONLY "PV" INDICATES ALL 12" SECTIONS PROGRAMMED VISIBILITY "8" INDICATES ALL 8" SECTIONS (ONLY WHEN SPECIFIED)
		VEHICLE SIGNAL HEAD CONSISTING OF RED, YELLOW AND GREEN LEFT ARROW SECTIONS
		VEHICLE SIGNAL HEAD CONSISTING OF RED AND YELLOW SECTIONS WITH AN UP GREEN ARROW SECTION
		VEHICLE SIGNAL HEAD (5 SECTION) CONSISTING OF RED, YELLOW AND GREEN SECTIONS WITH YELLOW AND GREEN RIGHT ARROW SECTIONS
		TYPE 15TS STANDARD WITH VEHICLE SIGNAL HEAD AND LUMINAIRE
		TYPE 21TS STANDARD WITH VEHICLE SIGNAL HEAD AND LUMINAIRE
		STANDARD WITH LUMINAIRE AND SIGNAL MAST ARMS AND ATTACHED VEHICLE SIGNAL HEADS
		TYPE 1 STANDARD WITH ATTACHED VEHICLE SIGNAL HEADS
		STANDARD WITH A SIGNAL MAST ARM, ATTACHED VEHICLE SIGNAL HEADS AND INTERNALLY ILLUMINATED STREET NAME SIGN
		CONTROLLER ASSEMBLY. DOOR INDICATES FRONT OF CABINET

SERVICE EQUIPMENT

NEW	EXISTING	
		OVERHEAD LINES
		WOOD POLE, "U" INDICATES UTILITY OWNED
		POLE GUY WITH ANCHOR
		UTILITY TRANSFORMER - GROUND MOUNTED
		SERVICE EQUIPMENT ENCLOSURE TYPE. DOOR INDICATES FRONT OF ENCLOSURE
		TELEPHONE DEMARCATION CABINET

POLE-MOUNTED SERVICE DESIGNATION

	TYPE H SERVICE, 28'-10"	TYPE OF INSTALLATION AND POLE HEIGHT ABOVE GRADE
--	-------------------------	--

FLASHING BEACON

NEW	EXISTING	
		FLASHING BEACON (ONE VEHICLE SIGNAL HEAD WITH BACKPLATE AND VISOR) "R" INDICATES RED INDICATION, "Y" INDICATES YELLOW INDICATION
		FLASHING BEACON WITH TYPE 15-FBS STANDARD AND A SIGN.
		FLASHING BEACON WITH TYPES 9, 9A OR 9B SIGN UNLESS OTHERWISE SPECIFIED OR INDICATED

SIGNAL EQUIPMENT Cont

NEW	EXISTING	
		GUARD POST
		TYPE 1 STANDARD WITH RAMP METERING SIGN
		OPTICAL DETECTOR FOR THE EMERGENCY VEHICLE DETECTION

NOTES:

- All signal sections shall be 12" unless shown otherwise.
- Signal heads shall be provided with backplates unless shown otherwise.

ILLUMINATED OVERHEAD SIGN

NEW	EXISTING	
		SINGLE POST, SINGLE ILLUMINATED SIGN, BALANCED BUTTERFLY
		SINGLE POST, DOUBLE ILLUMINATED SIGN, BALANCED BUTTERFLY
		SINGLE POST, SINGLE ILLUMINATED SIGN, FULL CANTILEVER
		DOUBLE POST, SINGLE ILLUMINATED SIGN
		SINGLE ILLUMINATED SIGN MOUNTED ON STRUCTURE
		DOUBLE POST, SINGLE ILLUMINATED SIGN WITH ELECTROLIER

STATE OF CALIFORNIA
DEPARTMENT OF TRANSPORTATION

**ELECTRICAL SYSTEMS
(LEGEND AND ABBREVIATIONS)**

NO SCALE

RSP ES-1B DATED OCTOBER 30, 2015 SUPERSEDES RSP ES-1B DATED JULY 19, 2013 AND STANDARD PLAN ES-1B DATED MAY 20, 2011 - PAGE 426 OF THE STANDARD PLANS BOOK DATED 2010.

REVISED STANDARD PLAN RSP ES-1B


2010 REVISED STANDARD PLAN RSP ES-1B




TO ACCOMPANY PLANS DATED 11-02-15

EQUIPMENT IDENTIFICATION


ILLUMINATED SIGN IDENTIFICATION NUMBER:

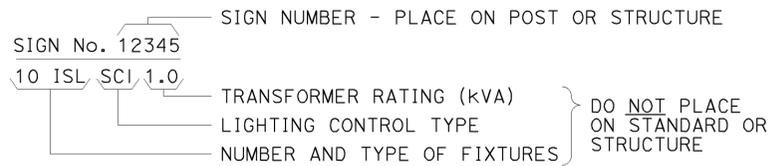


ELECTROLIER OR EQUIPMENT IDENTIFICATION NUMBER:

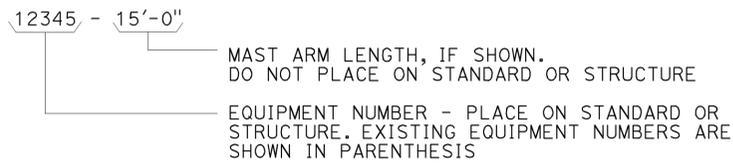


CONDUIT AND CONDUCTOR IDENTIFICATION:

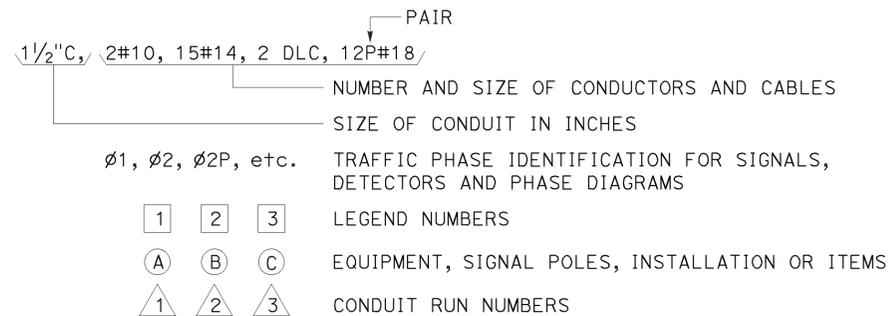


SIGNAL AND LIGHTING STANDARD (TYPICAL DESIGNATION):

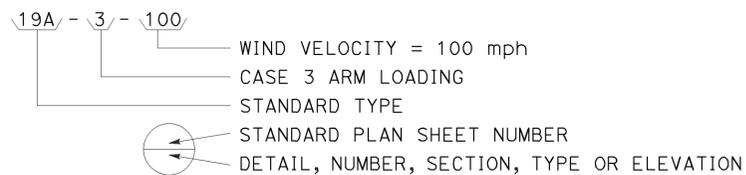


MISCELLANEOUS EQUIPMENT

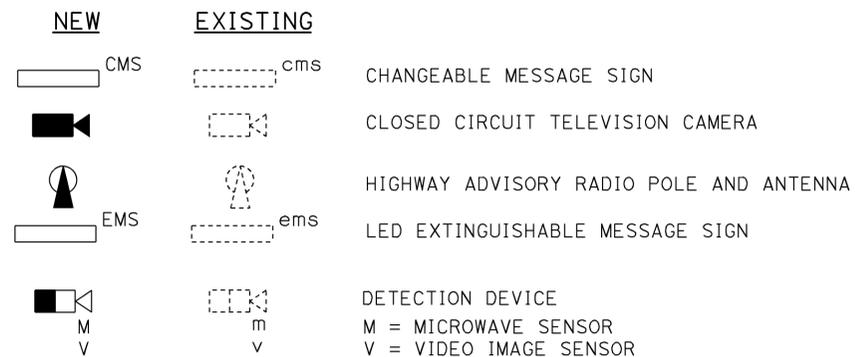



WIRING DIAGRAM LEGEND

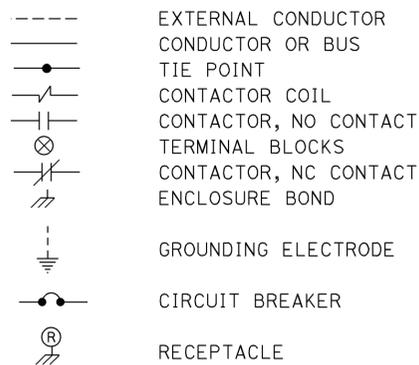

PULL BOXES

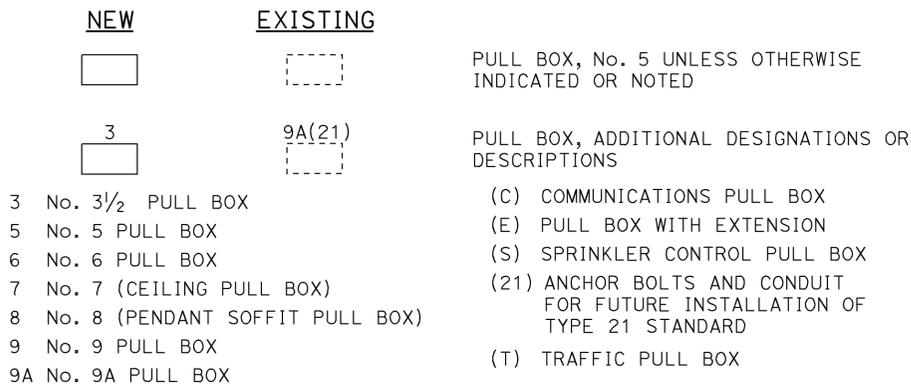

VEHICLE DETECTORS

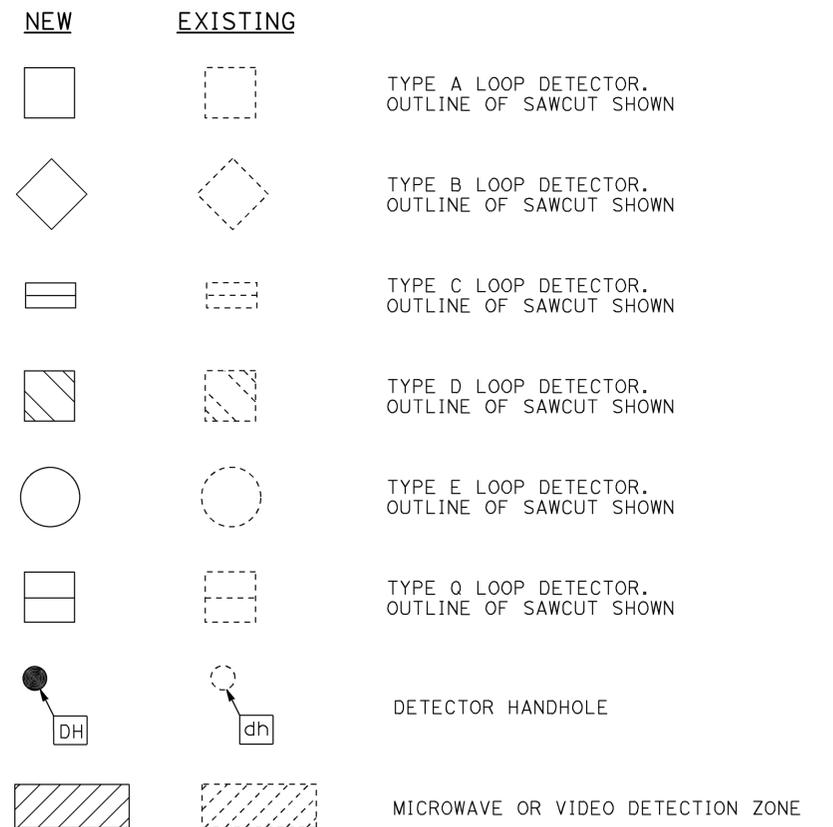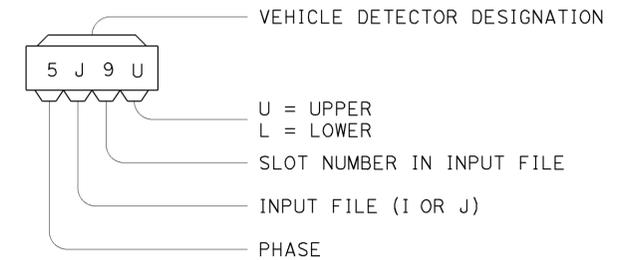

STATE OF CALIFORNIA
DEPARTMENT OF TRANSPORTATION

ELECTRICAL SYSTEMS (LEGEND AND ABBREVIATIONS)

NO SCALE


RSP ES-1C DATED OCTOBER 30, 2015 SUPERSEDES RSP ES-1C DATED JULY 19, 2013 AND STANDARD PLAN ES-1C DATED MAY 20, 2011 - PAGE 427 OF THE STANDARD PLANS BOOK DATED 2010.

REVISED STANDARD PLAN RSP ES-1C


2010 REVISED STANDARD PLAN RSP ES-1C

Dist	COUNTY	ROUTE	POST MILES TOTAL PROJECT	SHEET No.	TOTAL SHEETS
06	Fre	33	11.1/14.8, 16.9/22.7	17	20

Theresa Gabriel
 REGISTERED ELECTRICAL ENGINEER
 October 30, 2015
 PLANS APPROVAL DATE
 THE STATE OF CALIFORNIA OR ITS OFFICERS OR AGENTS SHALL NOT BE RESPONSIBLE FOR THE ACCURACY OR COMPLETENESS OF SCANNED COPIES OF THIS PLAN SHEET.

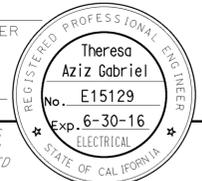


TO ACCOMPANY PLANS DATED 11-02-15

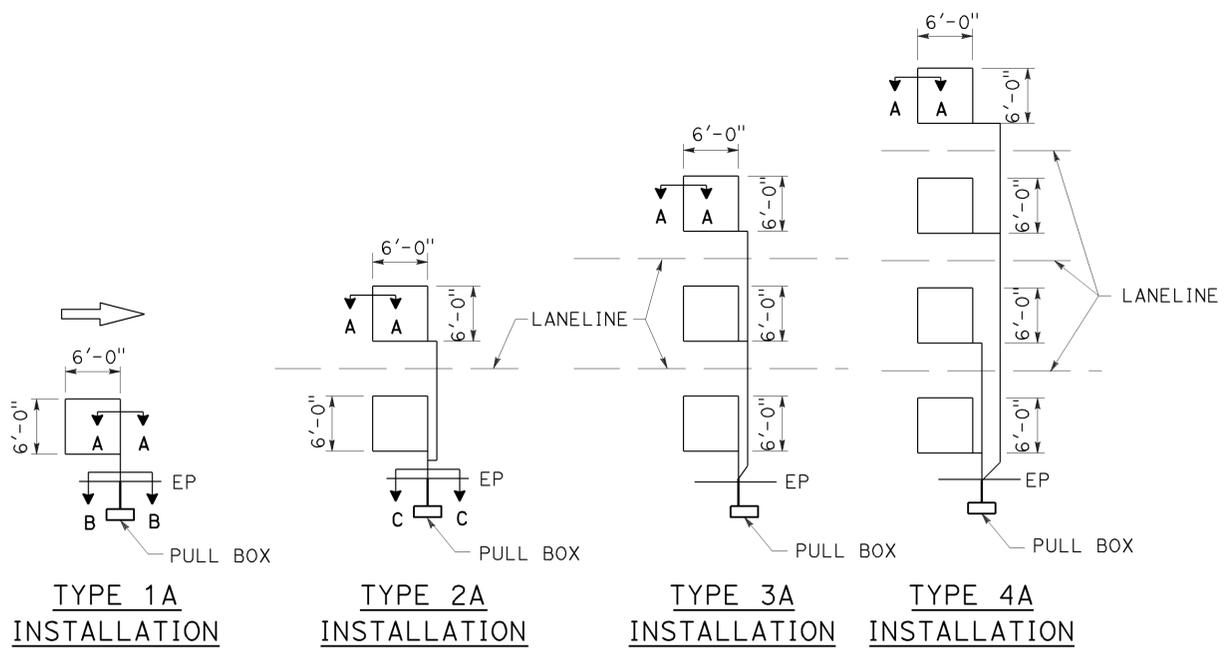


SAWCUT DETAILS

- Type A loop detector configurations illustrated
- 1A thru 4A = 1 Type A loop configuration in each lane.
 - 1B thru 4B = 1 Type B loop configuration in each lane.
 - 1C = 1 Type C loop configuration entering lanes as required.
 - 1D thru 4D = 1 Type D loop configuration in each lane.
 - 1E thru 4E = 1 Type E loop configuration in each lane.
 - 1Q thru 4Q = 1 Type Q loop configuration in each lane.
- Use Type A, B, C, D, E or Q loop detector configurations only when specified or shown on plans.

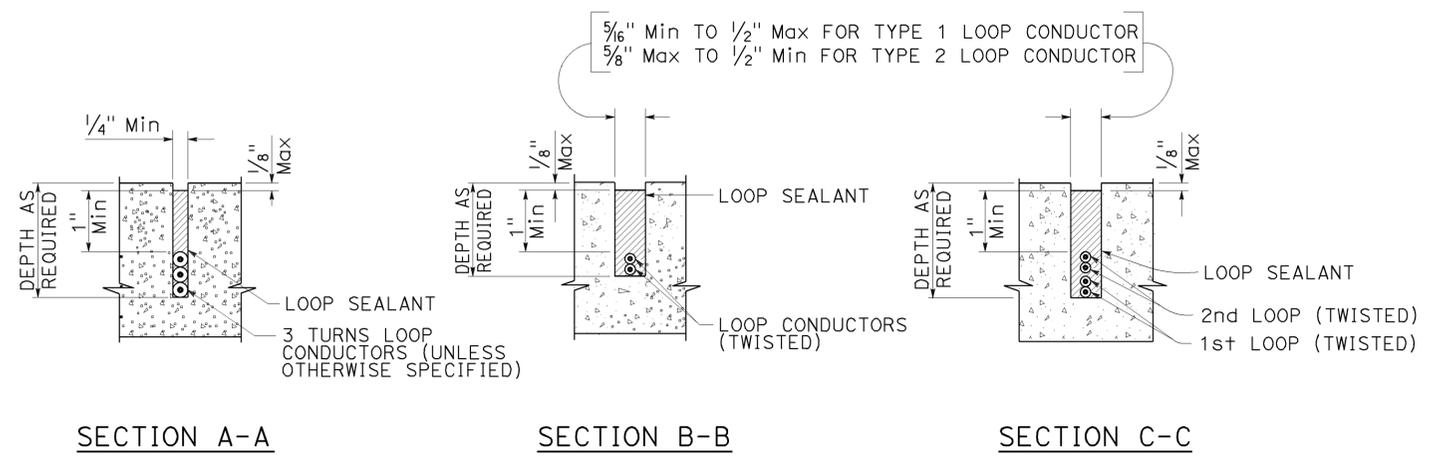


SLOT DETAILS - TYPE 1 AND TYPE 2 LOOP CONDUCTOR

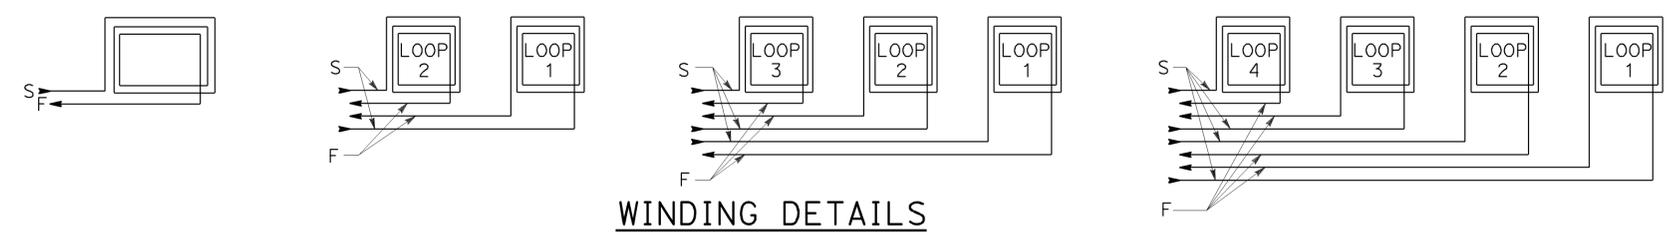

WINDING DETAILS

ABBREVIATIONS:
 S - START
 F - FINISH

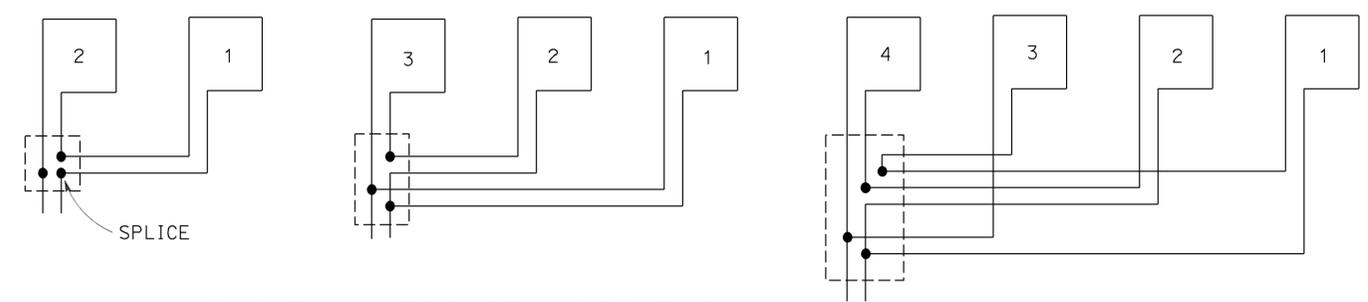

TYPICAL LOOP CONNECTIONS
 Dashed lines represent the pull box



STATE OF CALIFORNIA
 DEPARTMENT OF TRANSPORTATION
**ELECTRICAL SYSTEMS
 (LOOP DETECTORS)**
 NO SCALE

RSP ES-5A DATED OCTOBER 30, 2015 SUPERSEDES STANDARD PLAN ES-5A DATED MAY 20, 2011 - PAGE 448 OF THE STANDARD PLANS BOOK DATED 2010.


REVISED STANDARD PLAN RSP ES-5A

2010 REVISED STANDARD PLAN RSP ES-5A


Dist	COUNTY	ROUTE	POST MILES TOTAL PROJECT	SHEET No.	TOTAL SHEETS
06	Fre	33	11.1/14.8, 16.9/22.7	18	20
<i>Theresa Gabriel</i> REGISTERED ELECTRICAL ENGINEER October 30, 2015 PLANS APPROVAL DATE <small>THE STATE OF CALIFORNIA OR ITS OFFICERS OR AGENTS SHALL NOT BE RESPONSIBLE FOR THE ACCURACY OR COMPLETENESS OF SCANNED COPIES OF THIS PLAN SHEET.</small>					
TO ACCOMPANY PLANS DATED <u>11-02-15</u>					

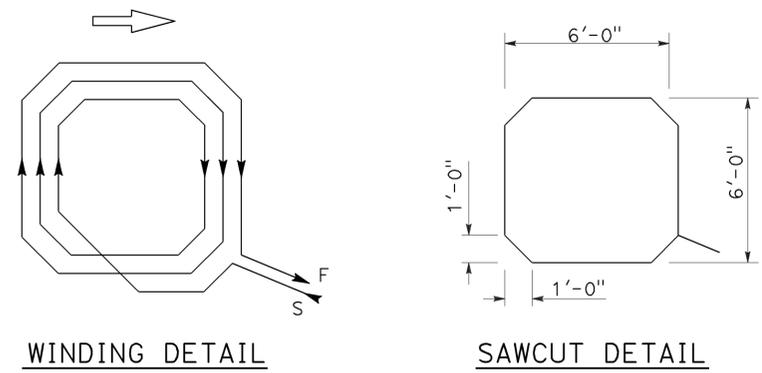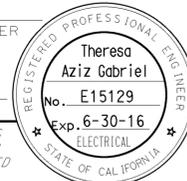


WINDING DETAIL
SAWCUT DETAIL
TYPE A LOOP DETECTOR CONFIGURATION

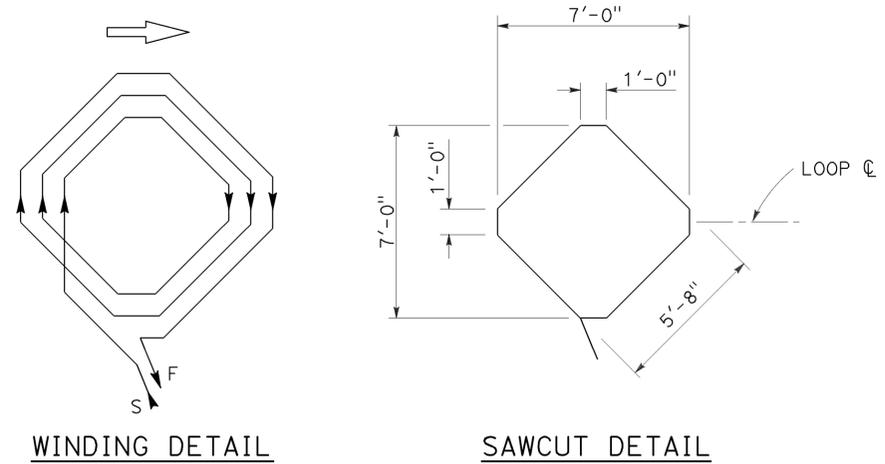


WINDING DETAIL
SAWCUT DETAIL
TYPE B LOOP DETECTOR CONFIGURATION

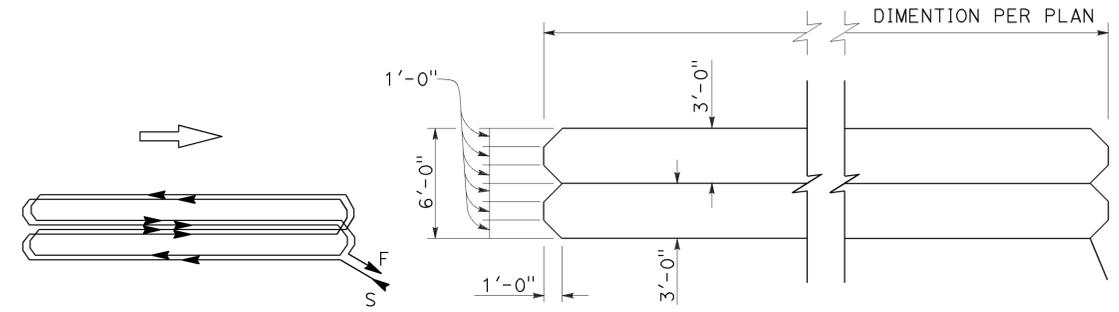


WINDING DETAIL
SAWCUT DETAIL
TYPE C LOOP DETECTOR CONFIGURATION

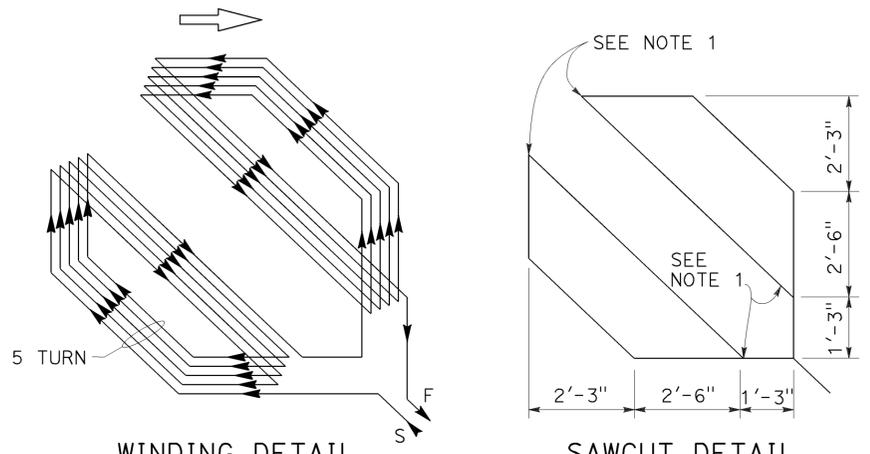


WINDING DETAIL
SAWCUT DETAIL
TYPE D LOOP DETECTOR CONFIGURATION

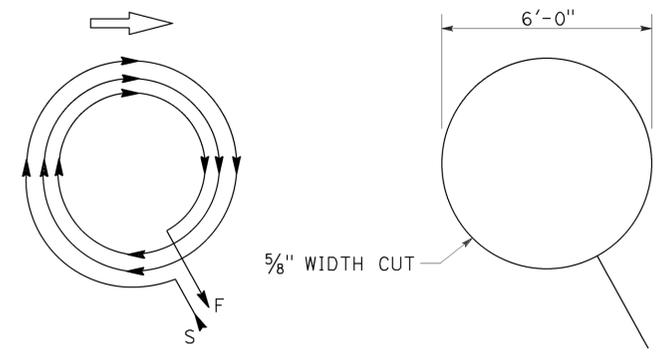

WINDING DETAIL
SAWCUT DETAIL
TYPE E LOOP DETECTOR CONFIGURATION

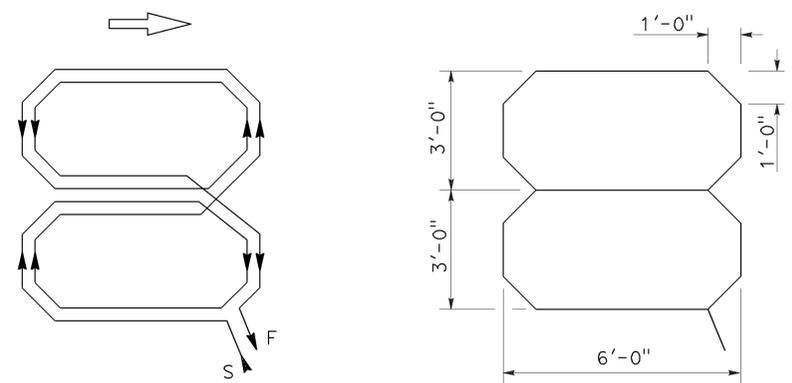

WINDING DETAIL
SAWCUT DETAIL
TYPE Q LOOP DETECTOR CONFIGURATION

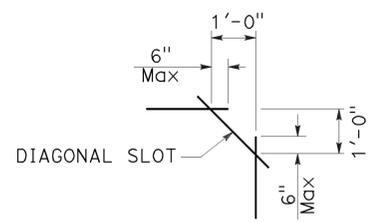

PLAN VIEW OF DIAGONAL SLOT AT CORNERS

- NOTES:**
1. Round corners of acute angle sawcuts to prevent damage to conductors.
 2. Typical distance separating loops from edge to edge is 10' for Type A, B, D and E installation in single lane.
 3. Use Type D loops for limit line detector installations in left turn and bicycle lanes.

STATE OF CALIFORNIA
DEPARTMENT OF TRANSPORTATION
ELECTRICAL SYSTEMS (DETECTORS)
NO SCALE

RSP ES-5B DATED OCTOBER 30, 2015 SUPERSEDES RSP ES-5B DATED JULY 19, 2013 AND STANDARD PLAN ES-5B DATED MAY 20, 2011 - PAGE 449 OF THE STANDARD PLANS BOOK DATED 2010.


2010 REVISED STANDARD PLAN RSP ES-5B

Dist	COUNTY	ROUTE	POST MILES TOTAL PROJECT	SHEET No.	TOTAL SHEETS
06	Fre	33	11.1/14.8, 16.9/22.7	19	20


Theresa Gabriel
 REGISTERED ELECTRICAL ENGINEER
 October 30, 2015
 PLANS APPROVAL DATE
THE STATE OF CALIFORNIA OR ITS OFFICERS OR AGENTS SHALL NOT BE RESPONSIBLE FOR THE ACCURACY OR COMPLETENESS OF SCANNED COPIES OF THIS PLAN SHEET.

REGISTERED PROFESSIONAL ENGINEER
 Theresa
 Aziz Gabriel
 No. E15129
 Exp. 6-30-16
 ELECTRICAL
 STATE OF CALIFORNIA


TO ACCOMPANY PLANS DATED 11-02-15

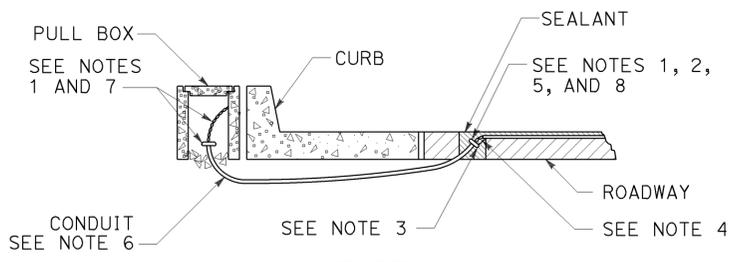


**TYPE A
CURB TERMINATION DETAIL**

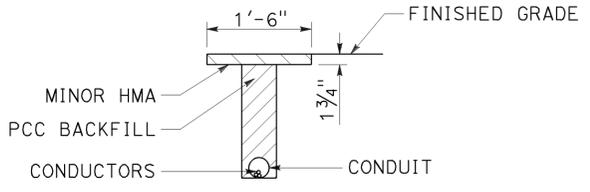


**"T" TRENCH
DETAIL 1**

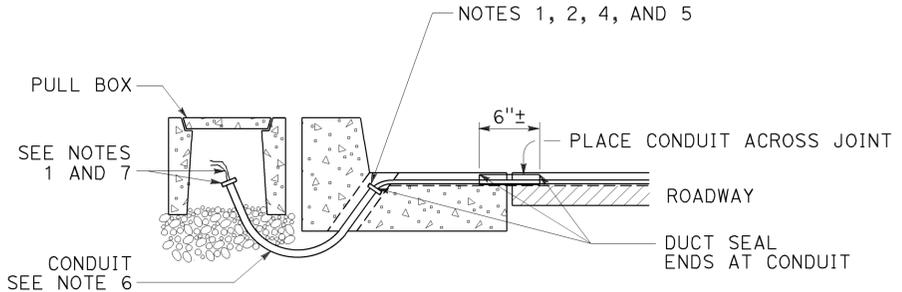

CROSS SECTION

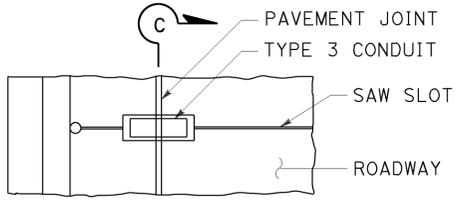


PLAN VIEW

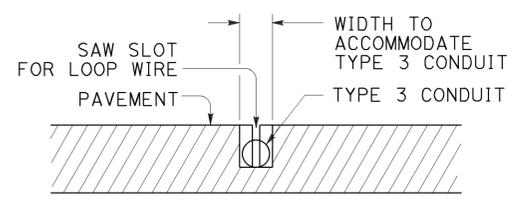


SECTION C-C


**TYPE B
CURB TERMINATION DETAIL**

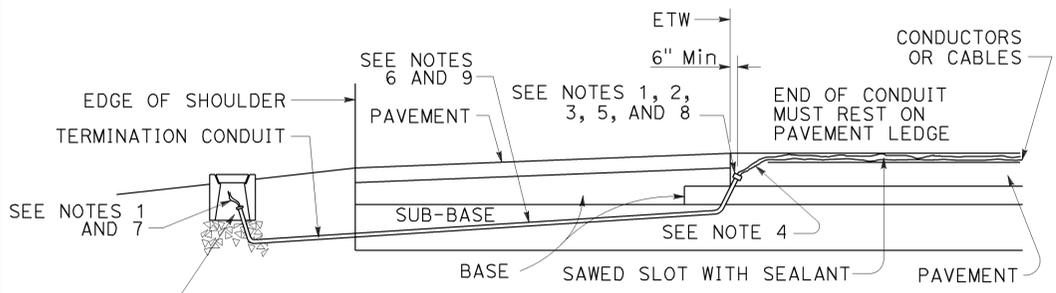


CROSS SECTION

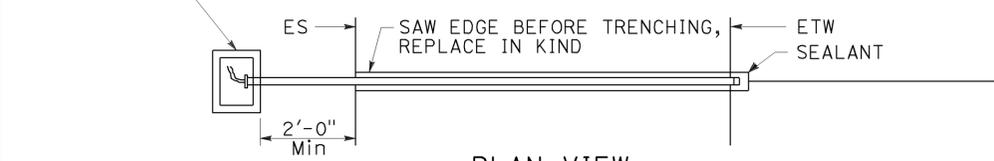


**PLAN VIEW
SHOULDER TERMINATION DETAILS**

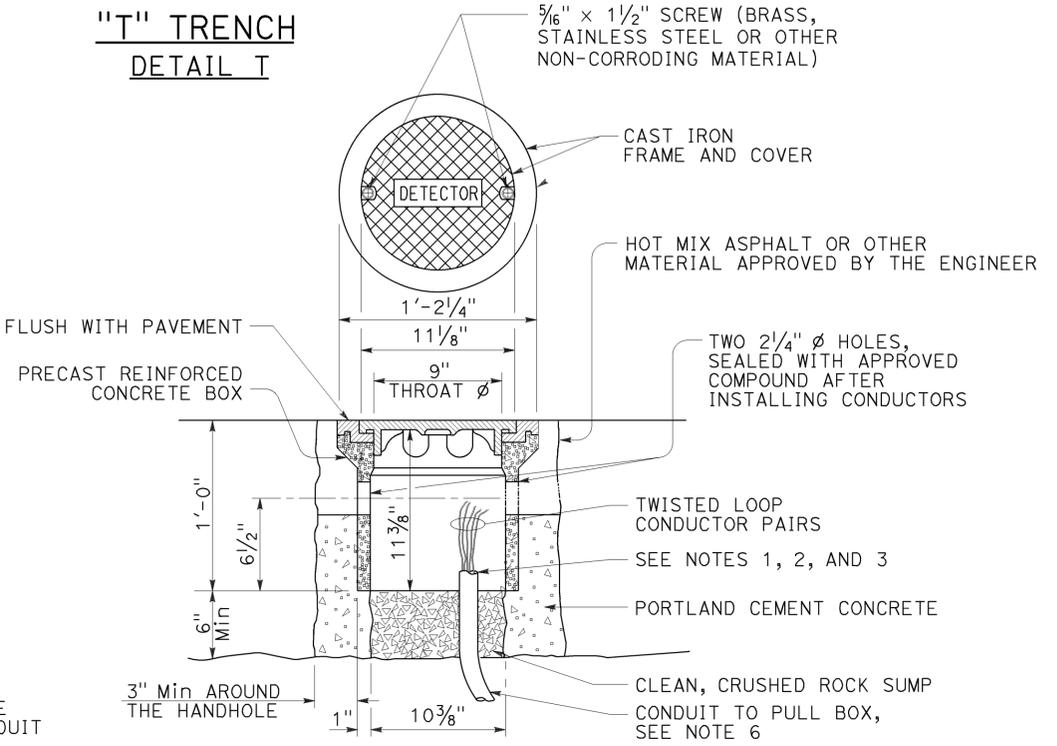


DETECTOR HANDHOLE DETAIL

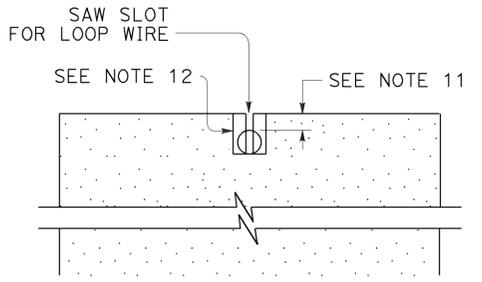

SECTION A-A

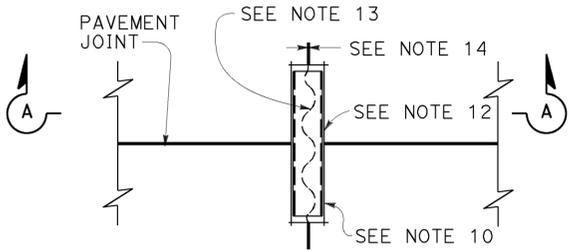

**PLAN VIEW
TYPICAL LOOP LEAD-IN DETAIL
AT PAVEMENT JOINT**

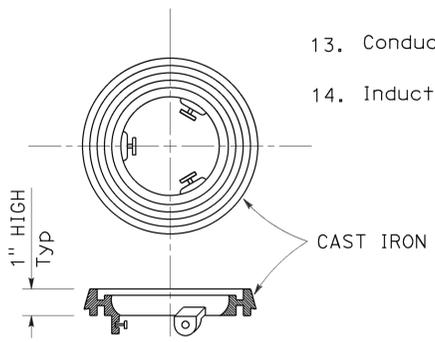

LOCKING GRADE RING

NOTES:

- Bushing shall be used at end of conduit.
- Tape detector conductors or cables 3" each side of bushings.
- Install duct seal compound to each end of termination conduit before installing sealant.
- Round all sharp edges where detector conductors or cables have to pass.
- End of conduit shall be 3/8" below roadway surface.
- | | |
|-----------------|-----------------|
| Conduit size | Loop conductors |
| 1"C minimum | 1 to 2 pairs |
| 1 1/2"C minimum | 3 to 4 pairs |
| 2"C minimum | 5 or more pairs |
- Splice detector conductors or cables to detector lead-in-cable.
- Location of detector handhole when shown on plans.
- When the shoulder and traveled way are paved with the same material and there is no joint between them, the conduit shall extend only 2'-0" into the shoulder pavement.
- 3/4"C, Type 3 conduit 6" long minimum, plug both ends with duct compound to keep out sealant.
- 1/2" Minimum between top of conduit and pavement surface.
- Sawcut shall not exceed 1" in width and 1/8" longer than conduit to be installed.
- Conductors with 1/2" minimum slack inside conduit.
- Inductive loop detector saw slot.

STATE OF CALIFORNIA
DEPARTMENT OF TRANSPORTATION


**ELECTRICAL SYSTEMS
(CURB AND SHOULDER TERMINATION,
TRENCH, AND HANDHOLE DETAILS)**

NO SCALE


RSP ES-5D DATED OCTOBER 30, 2015 SUPERSEDES RSP ES-5D DATED JULY 19, 2013 AND STANDARD PLAN ES-5D DATED MAY 20, 2011 - PAGE 451 OF THE STANDARD PLANS BOOK DATED 2010.

REVISED STANDARD PLAN RSP ES-5D

2010 REVISED STANDARD PLAN RSP ES-5D

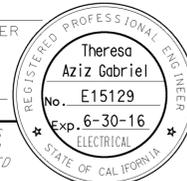
Dist	COUNTY	ROUTE	POST MILES TOTAL PROJECT	SHEET NO.	TOTAL SHEETS
06	Fre	33	11.1/14.8, 16.9/22.7	20	20
<i>Theresa Gabriel</i> REGISTERED ELECTRICAL ENGINEER					
October 30, 2015 PLANS APPROVAL DATE					
					
<small>THE STATE OF CALIFORNIA OR ITS OFFICERS OR AGENTS SHALL NOT BE RESPONSIBLE FOR THE ACCURACY OR COMPLETENESS OF SCANNED COPIES OF THIS PLAN SHEET.</small>					

TO ACCOMPANY PLANS DATED 11-02-15

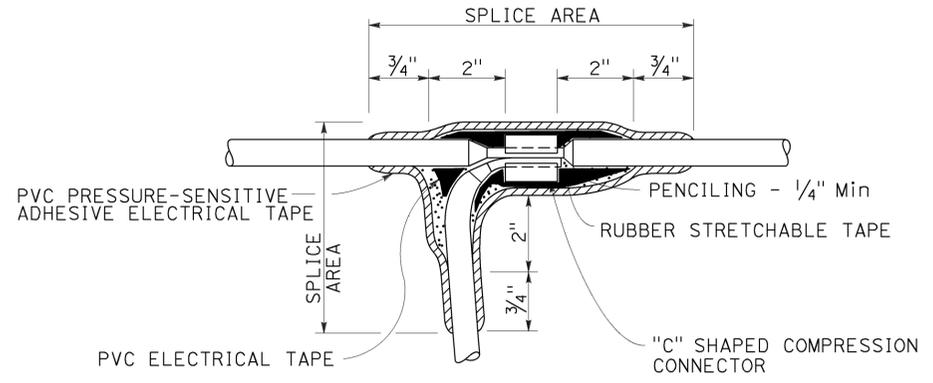

TYPE C SPLICE

See Note 3

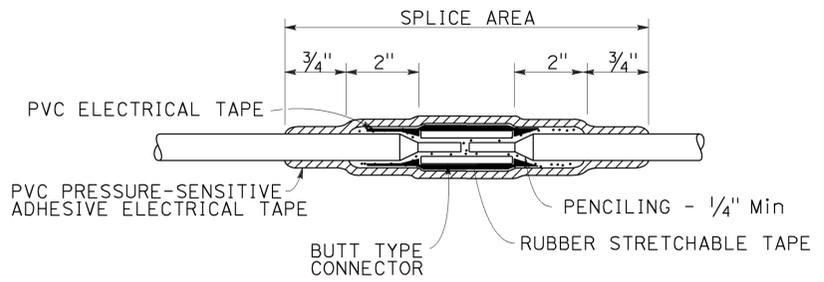


TYPE S SPLICE

See Note 4


NOTES:

1. Dimensions are minimum.
2. Rubber tapes shall be rolled after application.
3. Between 1 free-end and 1 through conductor.
4. Between 2 free-end conductors.
5. Between 3 free-end conductors.

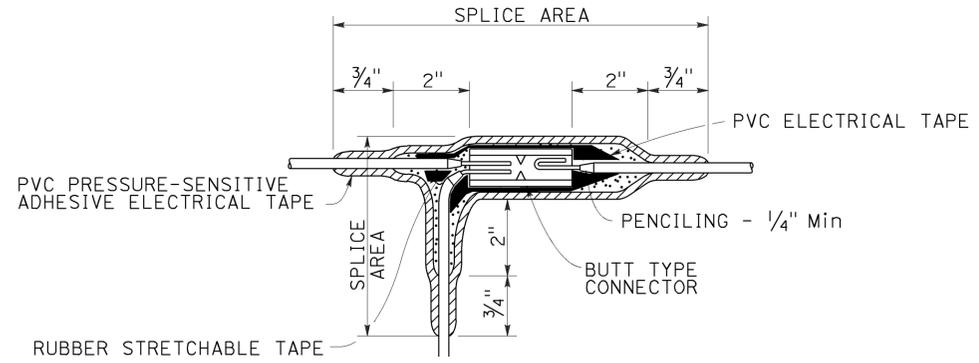

TYPE ST SPLICE

See Note 5

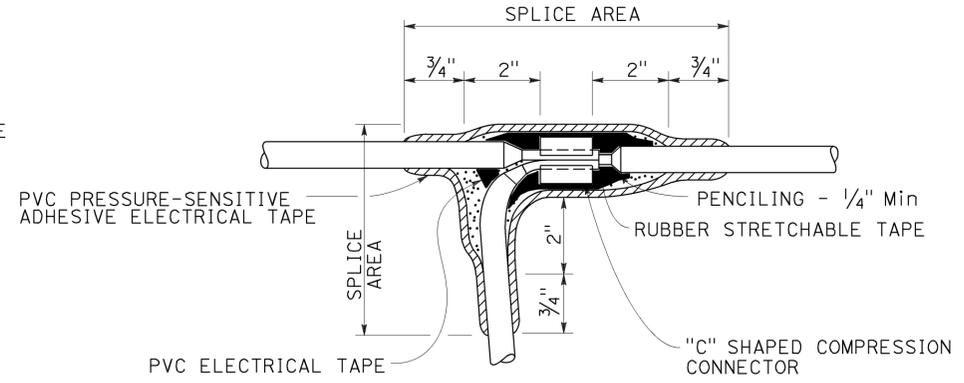

TYPE T SPLICE

See Note 5

STATE OF CALIFORNIA
DEPARTMENT OF TRANSPORTATION

**ELECTRICAL SYSTEMS
(SPLICING DETAILS)**

NO SCALE

RSP ES-13A DATED OCTOBER 30, 2015 SUPERSEDES STANDARD PLAN ES-13A DATED MAY 20, 2011 - PAGE 491 OF THE STANDARD PLANS BOOK DATED 2010.

REVISED STANDARD PLAN RSP ES-13A

2010 REVISED STANDARD PLAN RSP ES-13A